


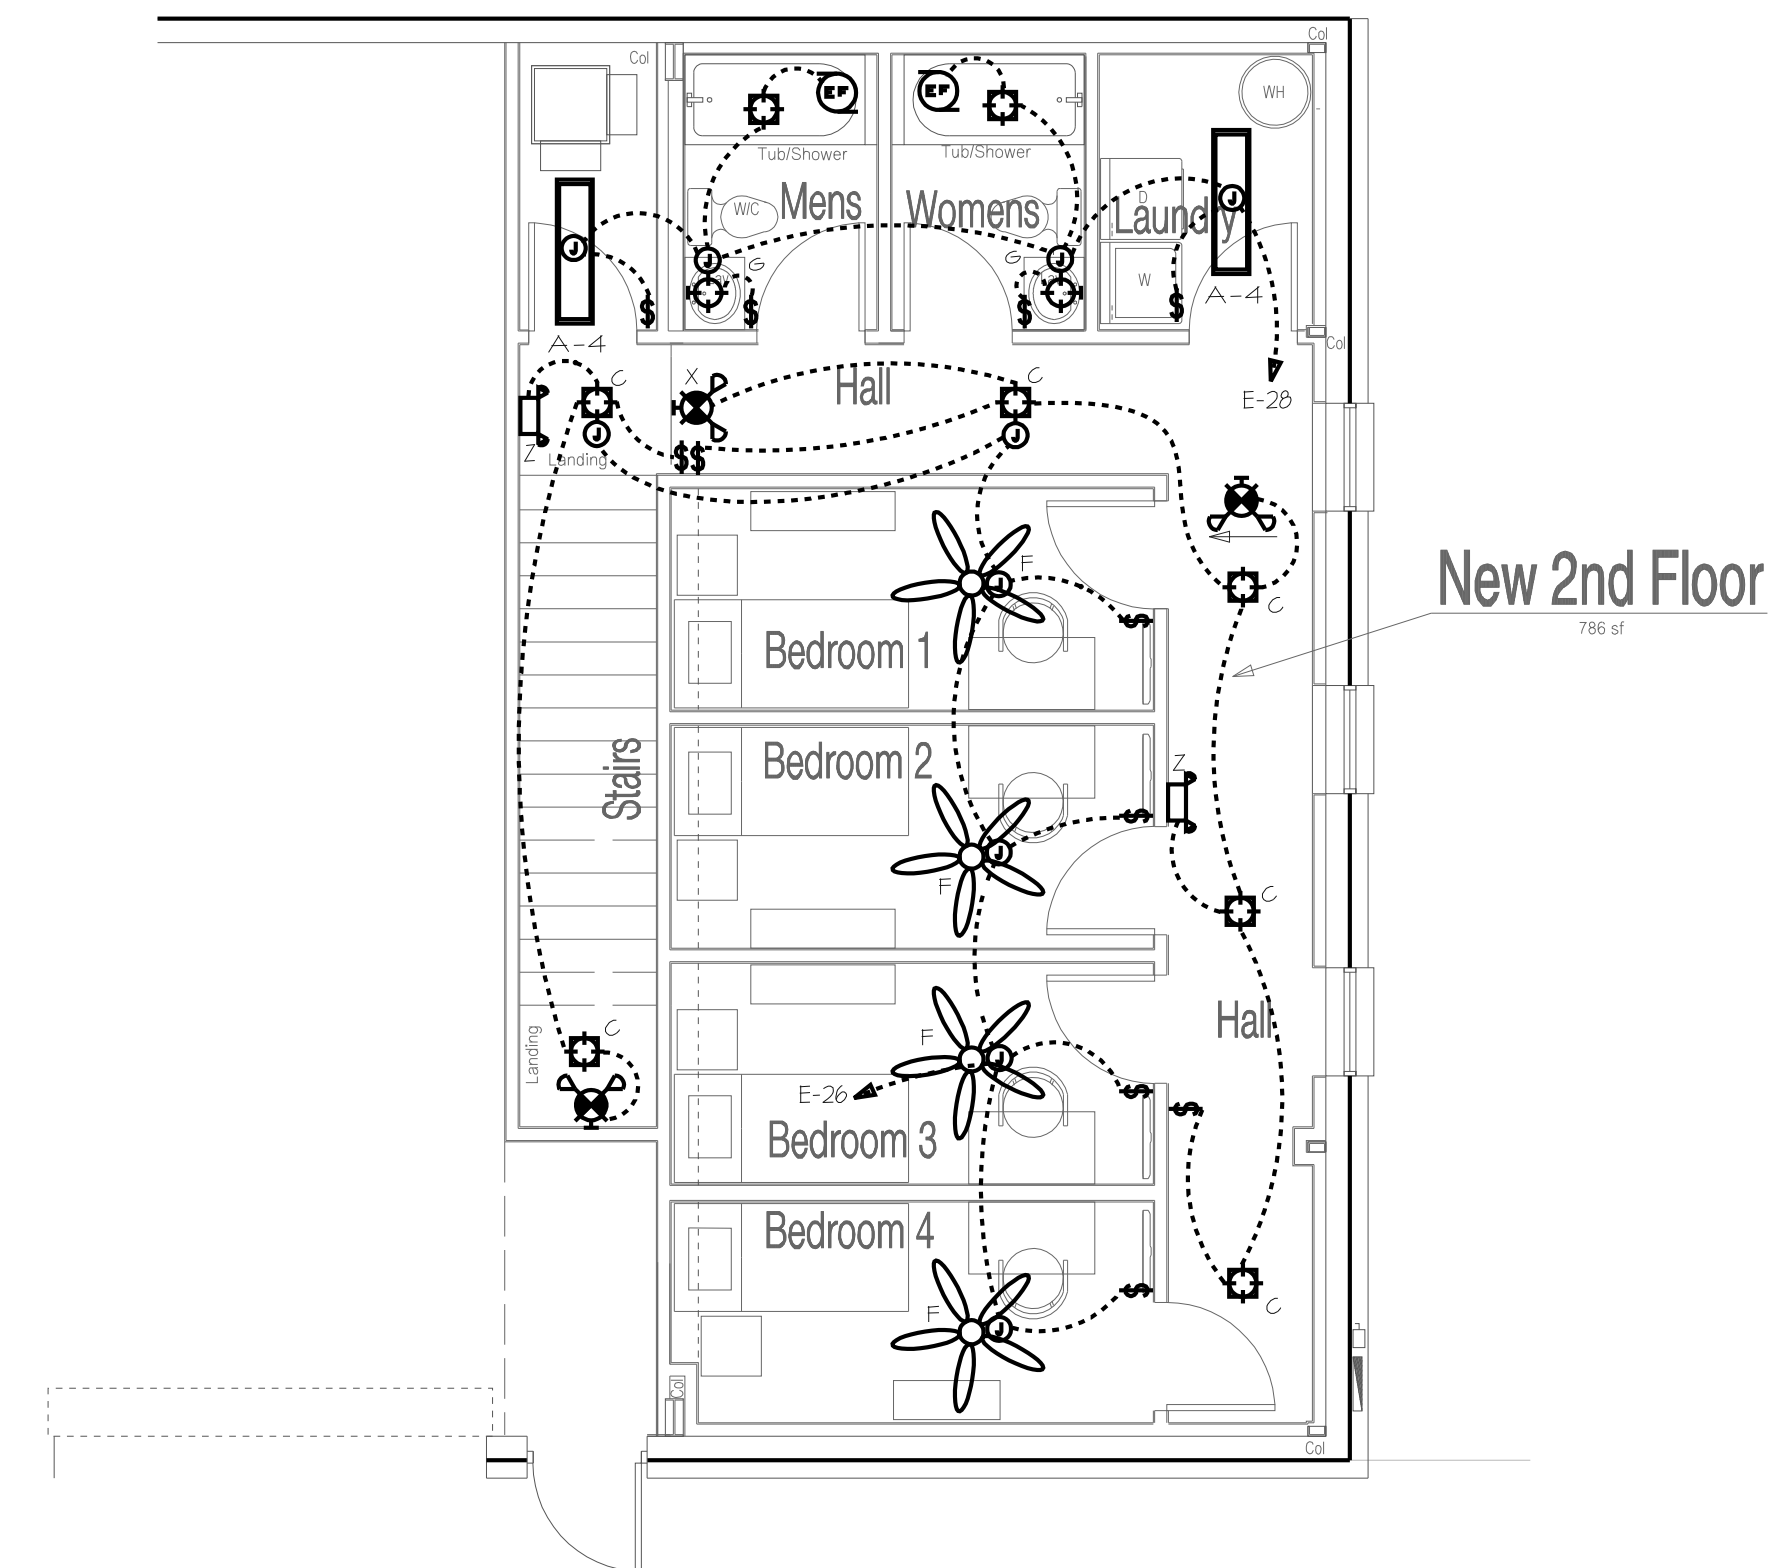

Electrical - Mezzanine Level Power Plan

Scale 1/8"=1'-0"

NOTICE

INDEX CODE

sda277 e200

REVISIONS

NO.	DATE & DESCRIPTION
-----	-----------------------

DATE OF DWG.

12 Aug. 2026

PRINTING DATE

SHEET NUMBER

E200

1 of 2

SDA Design Associates, LLC
4650 Lawrenceville Rd
Suite/Lt A15
Loganville, GA 30052
770.712.3472 info@sdaassociates.com


Project Name

Construction Document for
Banks County Fire Station
Fire Station 33
Banks County, Georgia


Sea



VERIFY ALL LIGHT FIXTURE SELECTIONS WITH OWNER PRIOR TO ORDERING & PLACEMENT
OF FIXTURES SHOWN BELOW ARE FOR REFERENCE ONLY

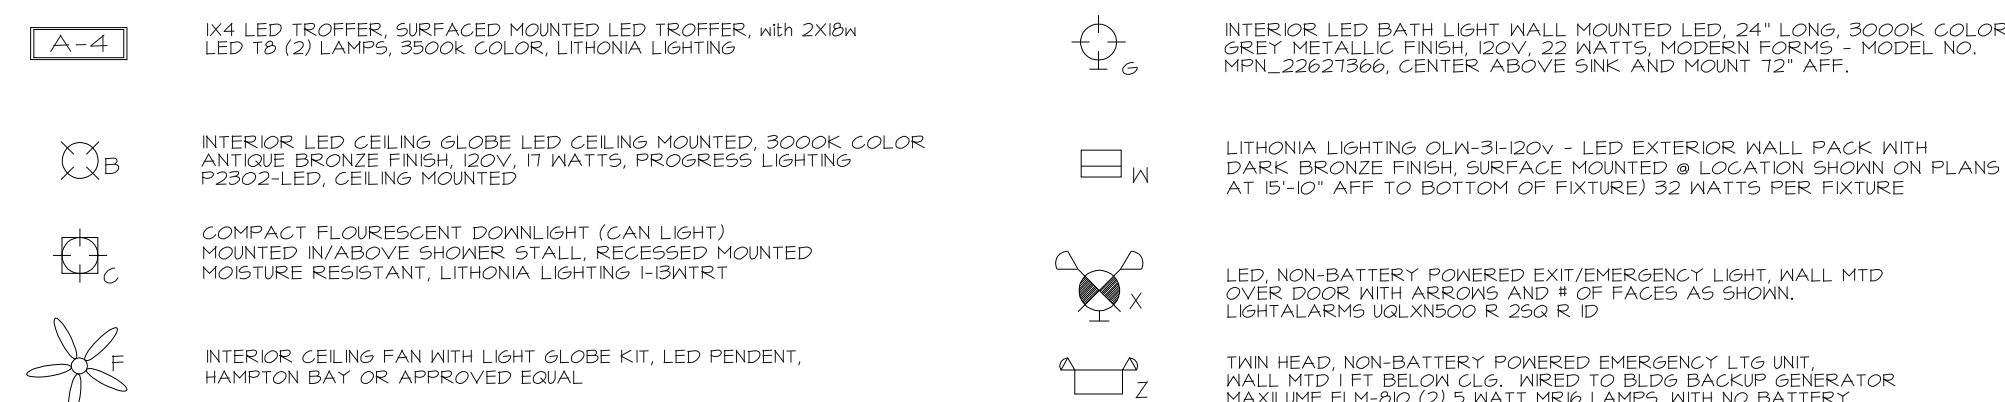

NOTE: FIXTURES SHOWN FOR REFERENCE, OWNER MAY CHOOSE THEIR OWN FIXTURES, STYLE AND MANUFACTURER

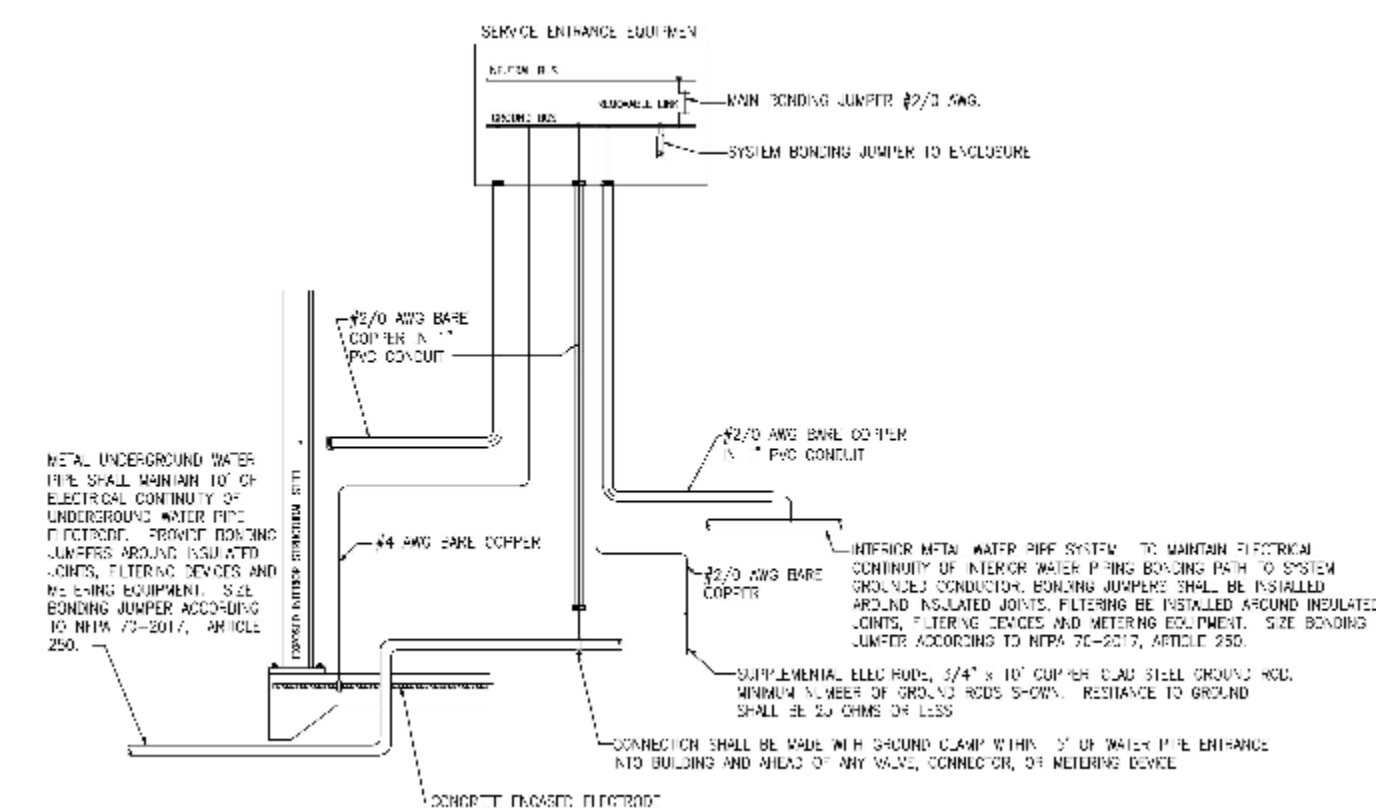

SCALE = NOT TO SCALE