


PRINTED: 8/31/2026 3:45:20 PM

FILEPATH: Autodesk Docs:\26-02527 Madison CA Fire Station\25-02527 Madison CA Fire Station V25.rvt

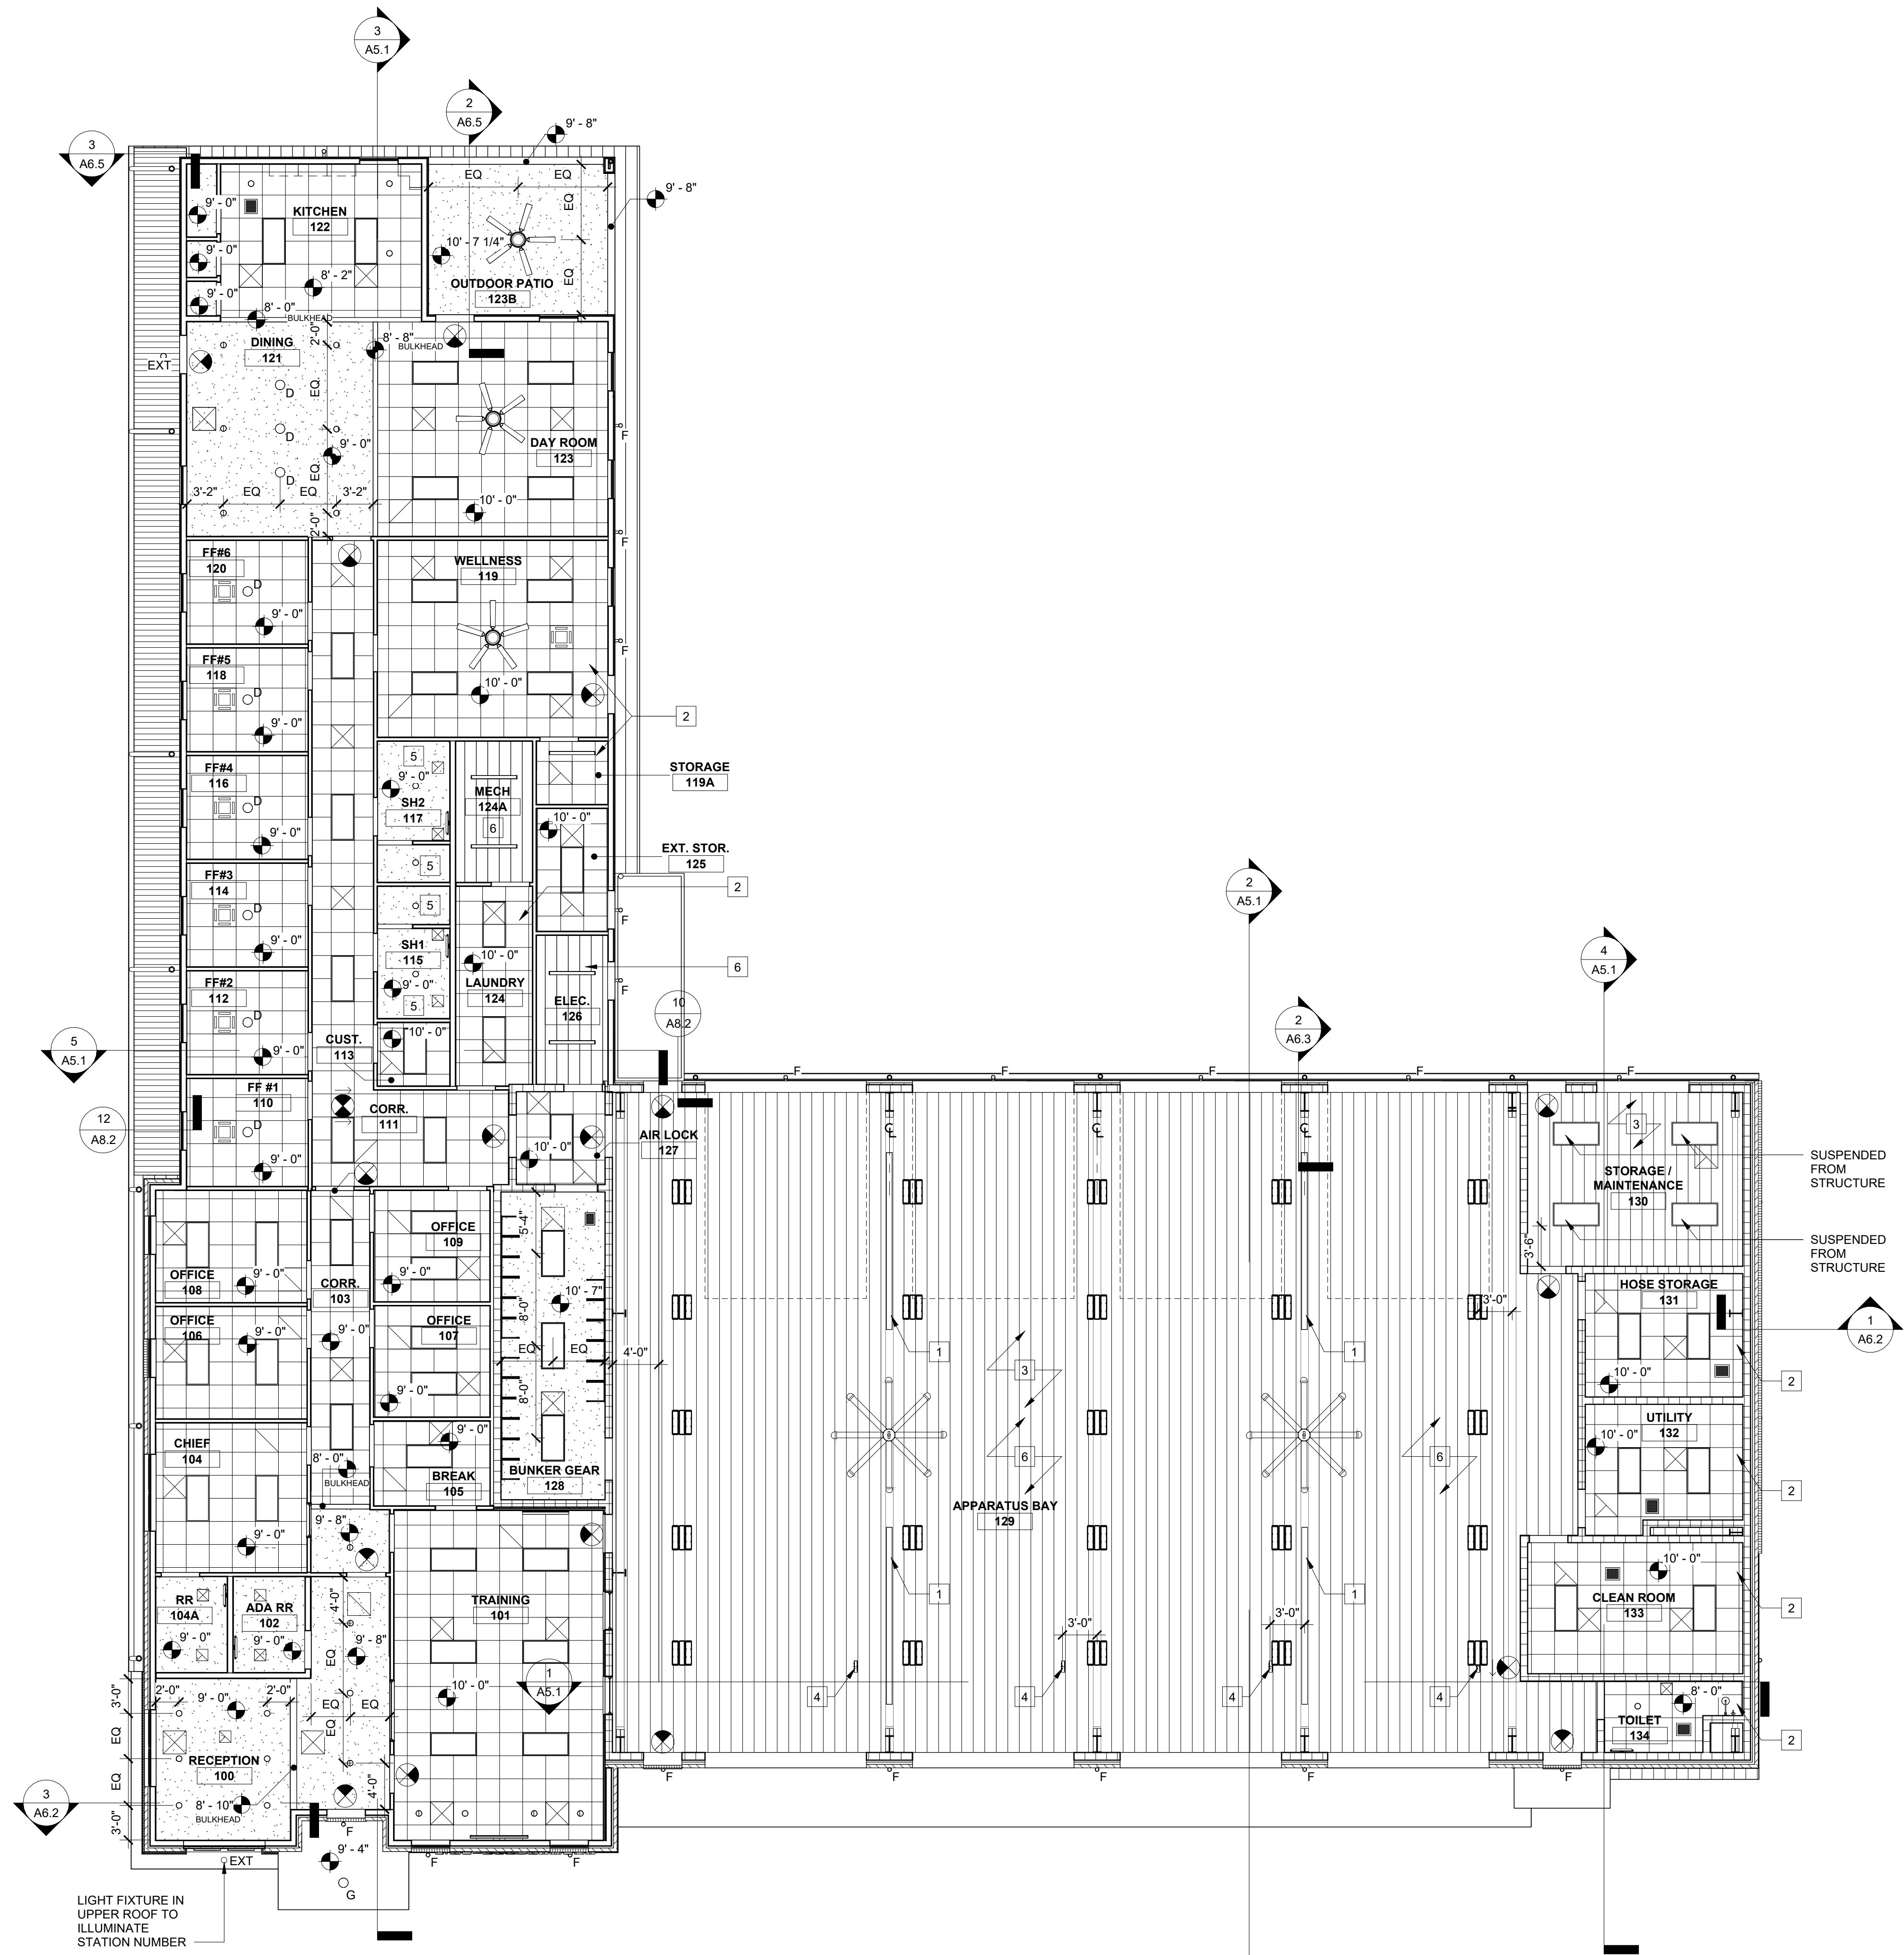

1 FIRST FLOOR REFLECTED CEILING PLAN
A9.1 SCALE: 1/8" = 1'-0"

GENERAL REFLECTED CEILING PLAN NOTES

- ALL ABOVE-CEILING AND EXPOSED SYSTEMS INSTALLATION BY SUBS TO BE COORDINATED WITH OTHER TRADES PRIOR TO BEGINNING WORK.
- ENGINEERING DRAWINGS TAKE PRECEDENCE FOR PARTICULAR FIXTURE TYPES. ARCHITECTURAL REFLECTED CEILING PLANS ARE FOR COORDINATION OF AESTHETIC ARRANGEMENTS.
- ENGINEERING DRAWINGS TAKE PRECEDENCE FOR SIZES OF DUCTWORK. ARCHITECTURAL REFLECTED CEILING PLANS ARE FOR COORDINATION OF AESTHETIC ARRANGEMENTS.
- CEILING HEIGHTS INDICATED ARE FROM TOP OF FINISH FLOOR TO UNDERSIDE OF FINISHED CEILING.
- ALL LAY-IN ACOUSTICAL CEILINGS TO BE ACT-1 WITH GRID 1 U.N.O.
- ALL EXPOSED CEILINGS TO BE PAINTED P-2, U.N.O.
- EXPOSED PIPING, CONDUIT, ETC. NOT SHOWN FOR CLARITY. ALL EXPOSED ELEMENTS SHALL BE PAINTED, UNO.
- ALL EXPOSED ELECTRICAL CONDUIT TO BE PAINTED TO MATCH ADJACENT SURFACES.
- REFER TO FINISH PLANS AND INTERIOR ELEVATIONS FOR ADDITIONAL FINISH INFORMATION. REFER TO SPECS FOR GWB TYPE DESIGNATIONS.

KEYED REFLECTED CEILING PLAN NOTES

- GAS FIRED RADIANT HEATING ELEMENT. COORD. W/ ELECTRICAL.
- EXTERIOR RATED FIBERGLASS ACOUSTICAL LAY-IN TILES INSTALLED ON CORROSION RESISTANT SUSPENSION SYSTEM
- SIMPLE SAVER ROOF INSULATION SYSTEM
- OVERHEAD RETRACTABLE COMMERCIAL EXTENSION CORD REEL
- INSTALL LIGHT CENTERED IN ROOM
- NO CEILING - EXPOSED TO STRUCTURE ABOVE

FIXTURE LEGEND

- EXT 6" RECESSED CAN LIGHT - EXTERIOR
- 6" RECESSED CAN LIGHT - INTERIOR
- MAXIM WAFER 9" DISC LED PANEL - BRONZE
- 2' x 4' LED LIGHT FIXTURE
- CAVITT 30" WIDE VANITY LIGHT, BRUSHED NICKEL
- 2' x 4' HIGH BAY LED CHAIN MOUNT
- 11" TALL LED OUTDOOR WALL SCONCE, RP LIGHTING 4424-13 OIL RUBBED BRONZE
- EXTERIOR WAC TUBE 12" WIDE OUTDOOR LED FLUSH MOUNT CEILING FIXTURE, OIL RUBBED BRONZE
- 4' LED LINEAR STRIP LIGHT WITH COLD GAUGE ROLLED STEEL HOUSING AND ACRYLIC LENS
- MINI SPLIT CEILING CASSETTE
- SUPPLY DIFFUSER
- RETURN DIFFUSER
- EXHAUST DIFFUSER
- EXHAUST FAN, SEE MECH. FOR SIZES
- Y LIGHTING COSMO FAN W/ LIGHT 70"
- 10' DIAMETER BIG ASS "ESSENCE" FAN (ALTERNATE #2)

FINISH SYMBOLS LEGEND


- | CEILING HEIGHT | REMARKS |
|----------------|--|
| 10'-0" | LAY-IN ACOUSTICAL CEILING
ARMSTRONG DUNE #1772 - 24"X24"X5/8" - WHITE
W/ PRELUDE 15/16" GRID |
| | EXTERIOR RATED FIBERGLASS LAY-IN ACOUSTICAL
CEILING TILES INSTALLED ON CORROSION RESISTANT
SUSPENSION SYSTEM |
| | GWB CEILING |
| | PAINTED EXPOSED STRUCTURE |
| | SIMPLE SAVER ROOF INSULATION SYSTEM |

REMARKS

A. NOT USED



11 Ninth Street, Suite 120
Columbus, GA 31901
P. (706) 571-6923

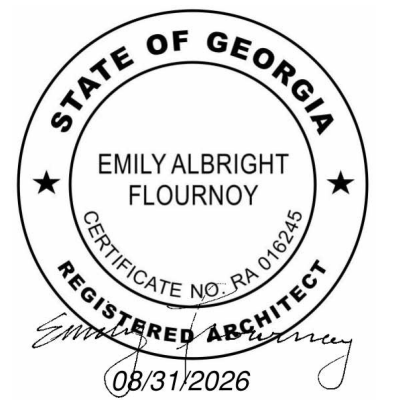

RFP 2027-3500-01

FIRE STATION MADISON, GA

1100 MARY MAGNAN BLVD
MADISON, GA 30650

BID DOCUMENTS

Project No.: 25-02527
Date: 08/31/26
Drawn by: EE
Checked by: WAG
Revisions:

No.	Date	Description
-----	------	-------------

REFLECTED
CEILING PLAN

A9.1