


PRINTED: 31-08-2026 20:28:56

FILE PATH: Autodesk Docs/REVIT 2025/26DLS035 Madison GA Fire Station, REStL MEP_R25.rvt

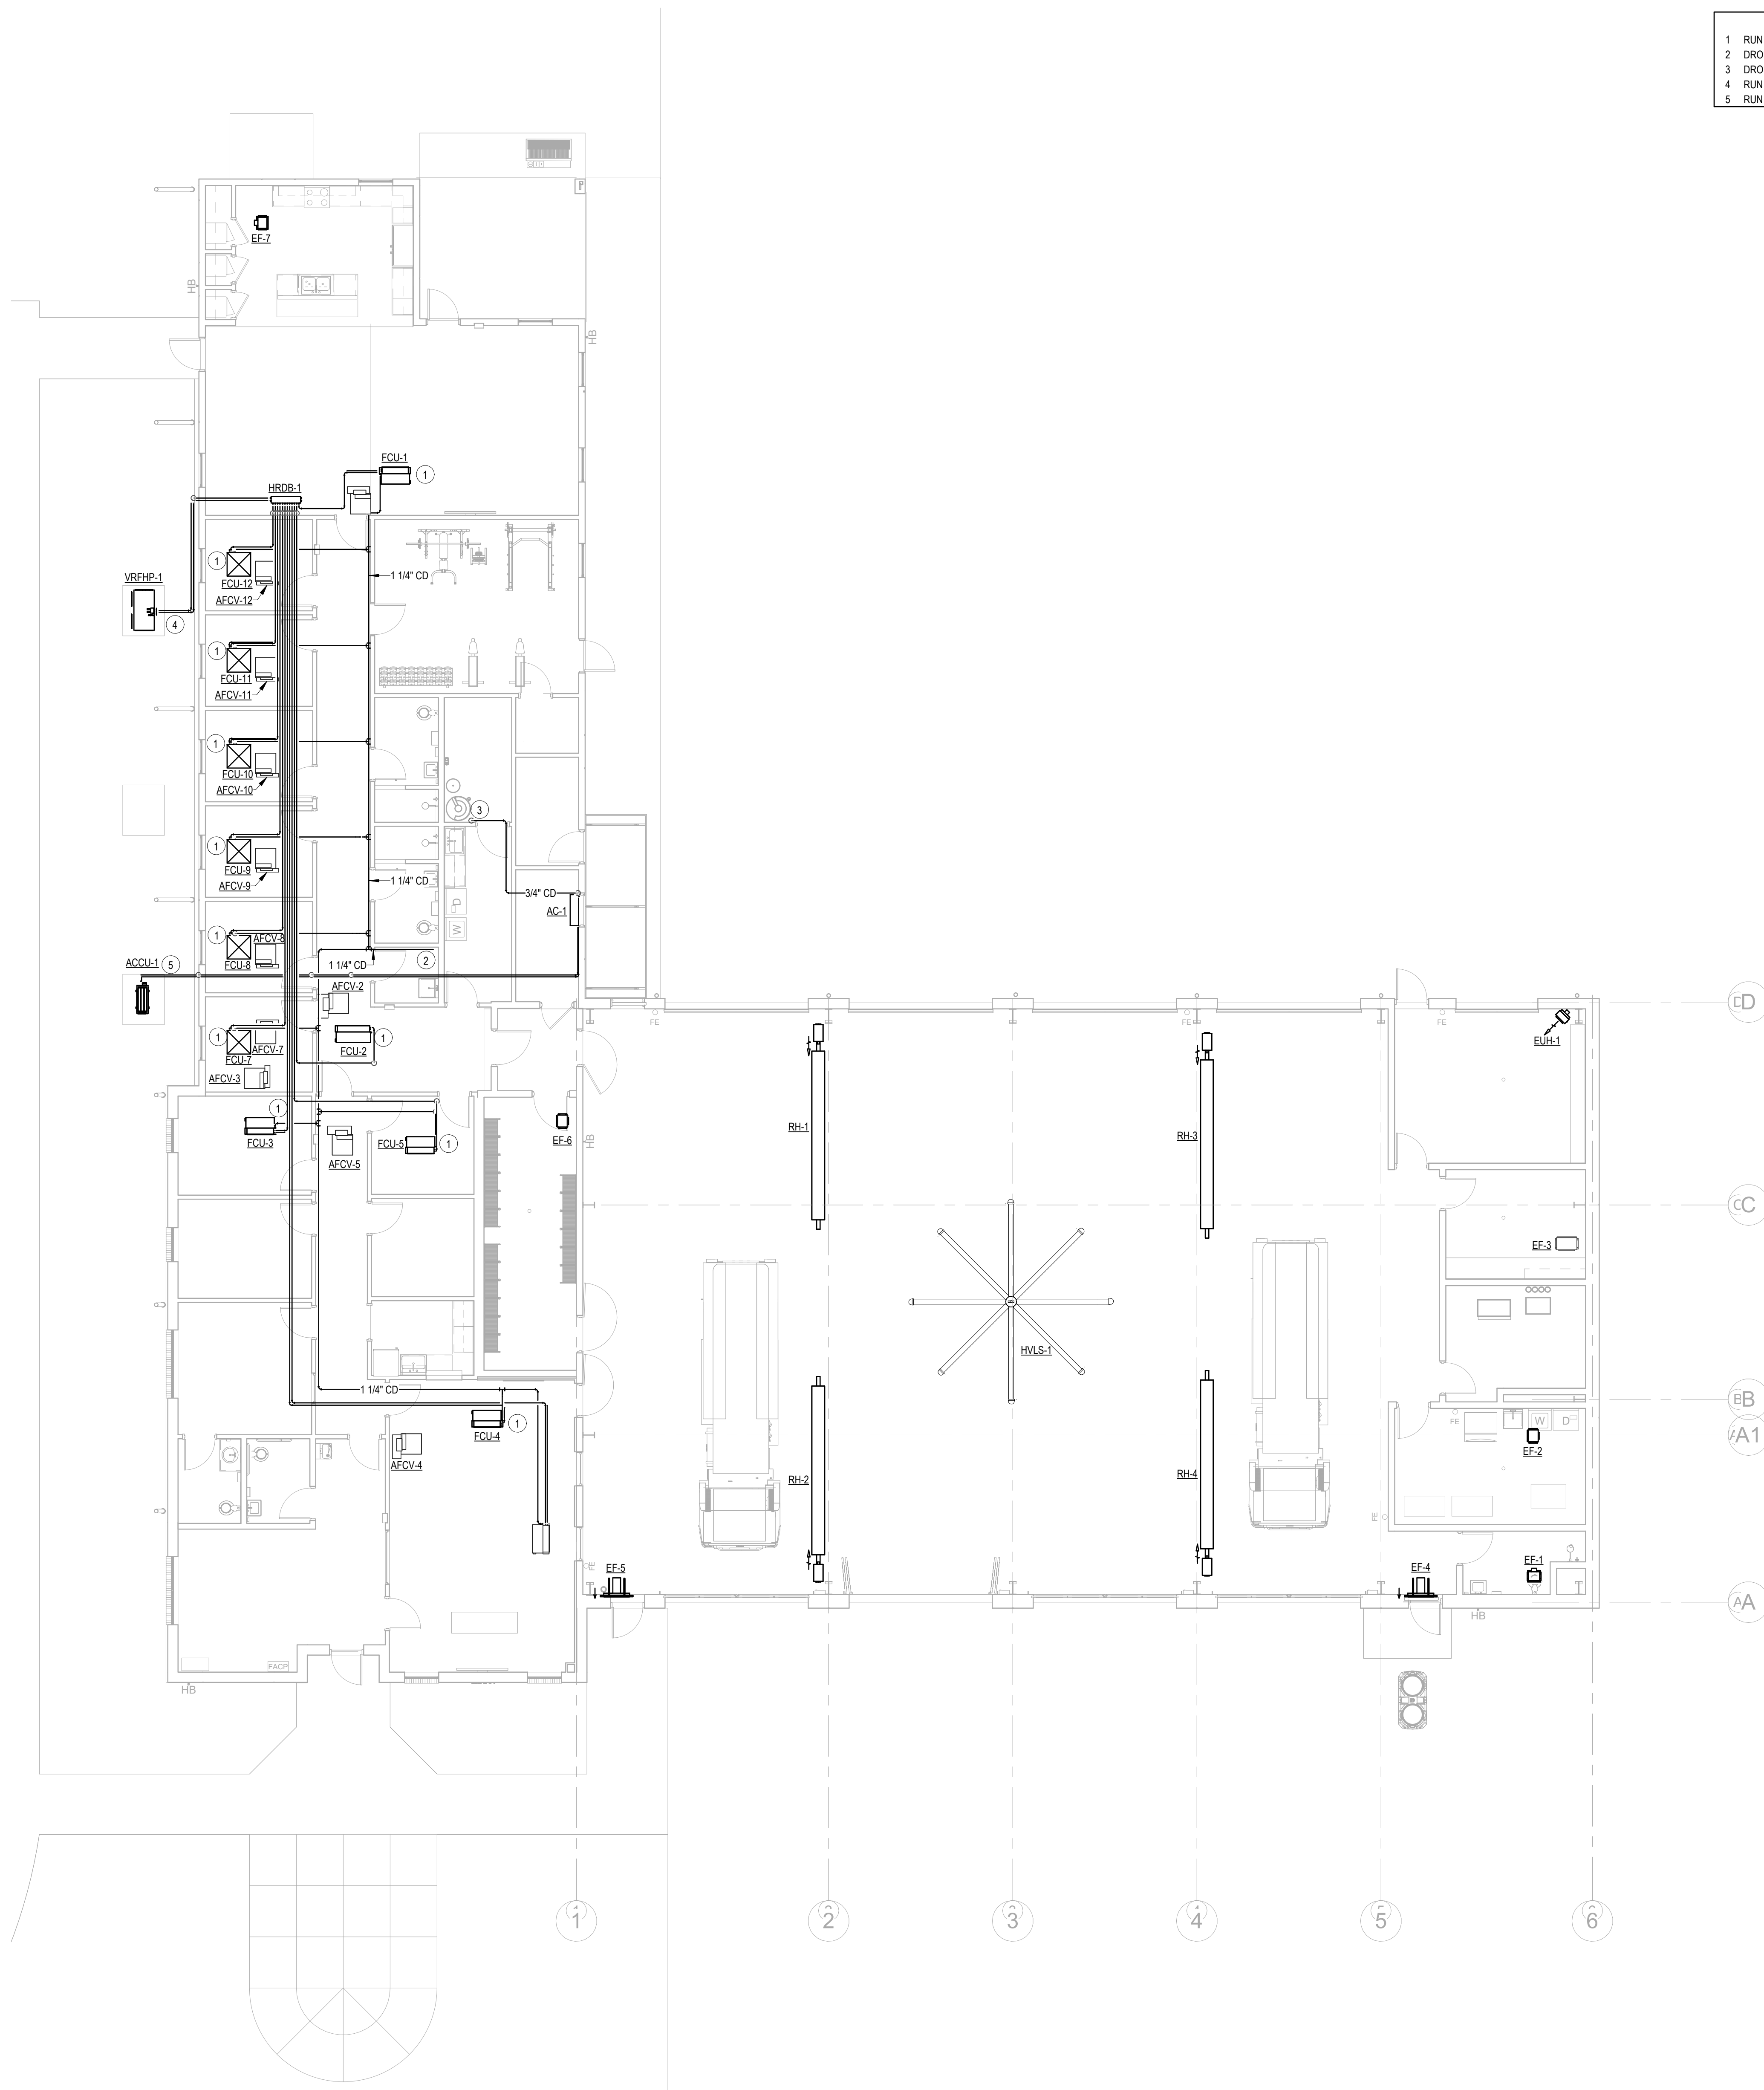

PLAN NOTES

- 1 RUN 1 1/4" CONDENSATE DRAIN PIPE TO MAIN PIPE RUN.
- 2 DROP 1 1/4" CONDENSATE DRAIN PIPE TO NEAREST FLOOR DRAIN/PO SINK.
- 3 DROP DOWN 3/4" CONDENSATE DRAIN PIPE TO NEAREST FLOOR DRAIN.
- 4 RUN 1 1/8" & 7/8" GAS AND LIQUID PIPES UPTO HRDB-1.
- 5 RUN 1/2" & 1/4" GAS AND LIQUID PIPES UPTO AC-1.

1 FIRST FLOOR MECHANICAL PIPING PLAN
1/8" = 1'-0"



11 Ninth Street, Suite 120
Columbus, GA 31901
P. (706) 571-6923



5757 Alpha Road, Suite 201
Dallas, TX 75201



RFP 2027-3500-01

FIRE STATION MADISON, GA

1100 MARY MAGNAN BLVD
MADISON, GA 30650

BID DOCUMENTS

Project No.: 25-02527
Date: 08/31/26
Drawn by: VRJ
Checked by: ANM
Revisions:

No.	Date	Description
-----	------	-------------

FIRST FLOOR
MECHANICAL
PIPING PLAN

M310