


PRINTED: 8/31/2026 5:05:21 PM

FILE PATH: Autocad Docs/REVIT 2025/26DLS035 Madison GA Fire Station, RESTL MEP P25.rvt

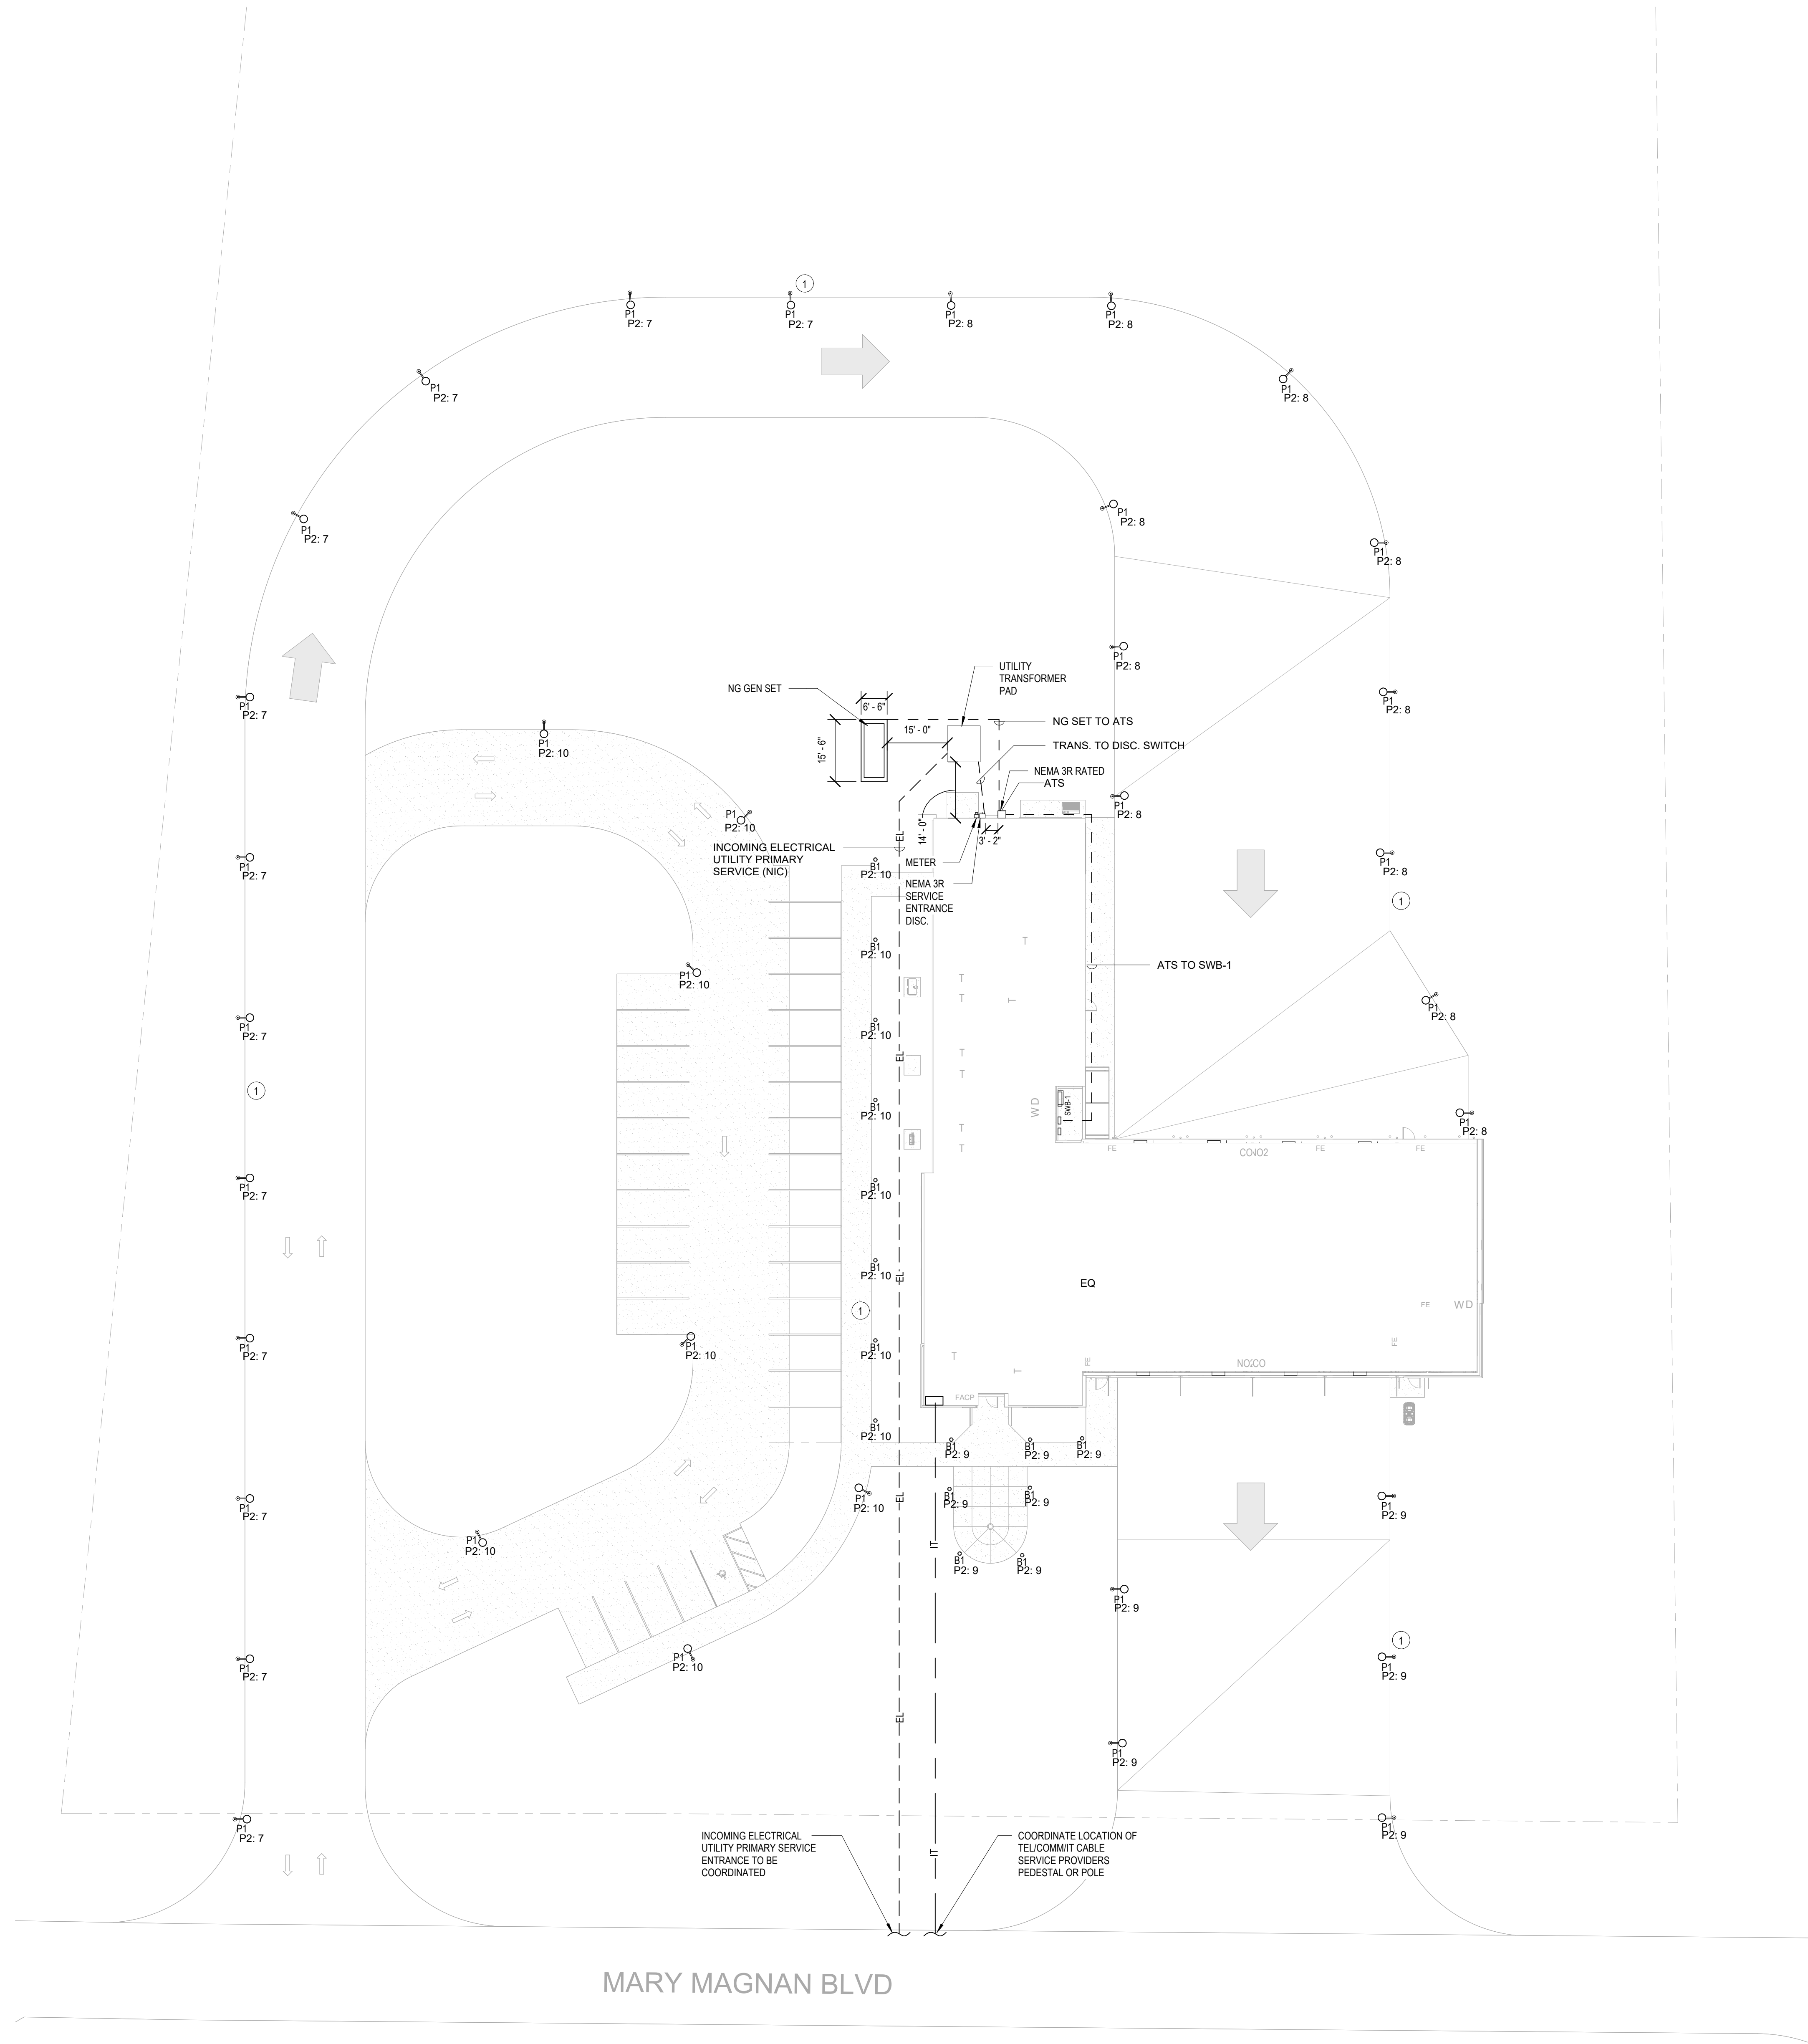

PLAN NOTES
1 ALL EXTERIOR LIGHTING SHALL BE CONTROLLED BY A PHOTOCELL AND TIME SWITCH TO ENSURE AUTOMATIC OPERATION BASED ON AMBIENT DAYLIGHT LEVELS AND SCHEDULED TIME SETTINGS.



11 Ninth Street, Suite 120
Columbus, GA 31901
P. (706) 571-6923



5757 Alpha Road, Suite 201
Dallas, TX 75201



RFP 2027-3500-01

FIRE STATION MADISON, GA

1100 MARY MAGNAN BLVD
MADISON, GA 30650

BID DOCUMENTS

Project No.: 25-02527
Date: 08/31/26
Drawn by: VVR
Checked by: CM
Revisions:

No.	Date	Description
-----	------	-------------

ELECTRICAL
SITE PLAN

E002