

RFP 2027-3500-01

FIRE STATION MADISON, GA

1100 MARTIN LUTHER KING, JR. BLVD
MADISON, GA 30650

BID DOCUMENTS


Project No.:	25-02527
Date:	08/31/26
Drawn by:	VVR
Checked by:	CM
Revisions:	

No.	Date	Description
-----	------	-------------

FIRST FLOOR LIGHTING PLAN

E210

1 ALL EXTERIOR LIGHTING SHALL BE CONTROLLED BY A PHOTOCELL AND TIME SWITCH TO ENSURE AUTOMATIC OPERATION BASED ON AMBIENT DAYLIGHT LEVELS AND SCHEDULED TIME SETTINGS.

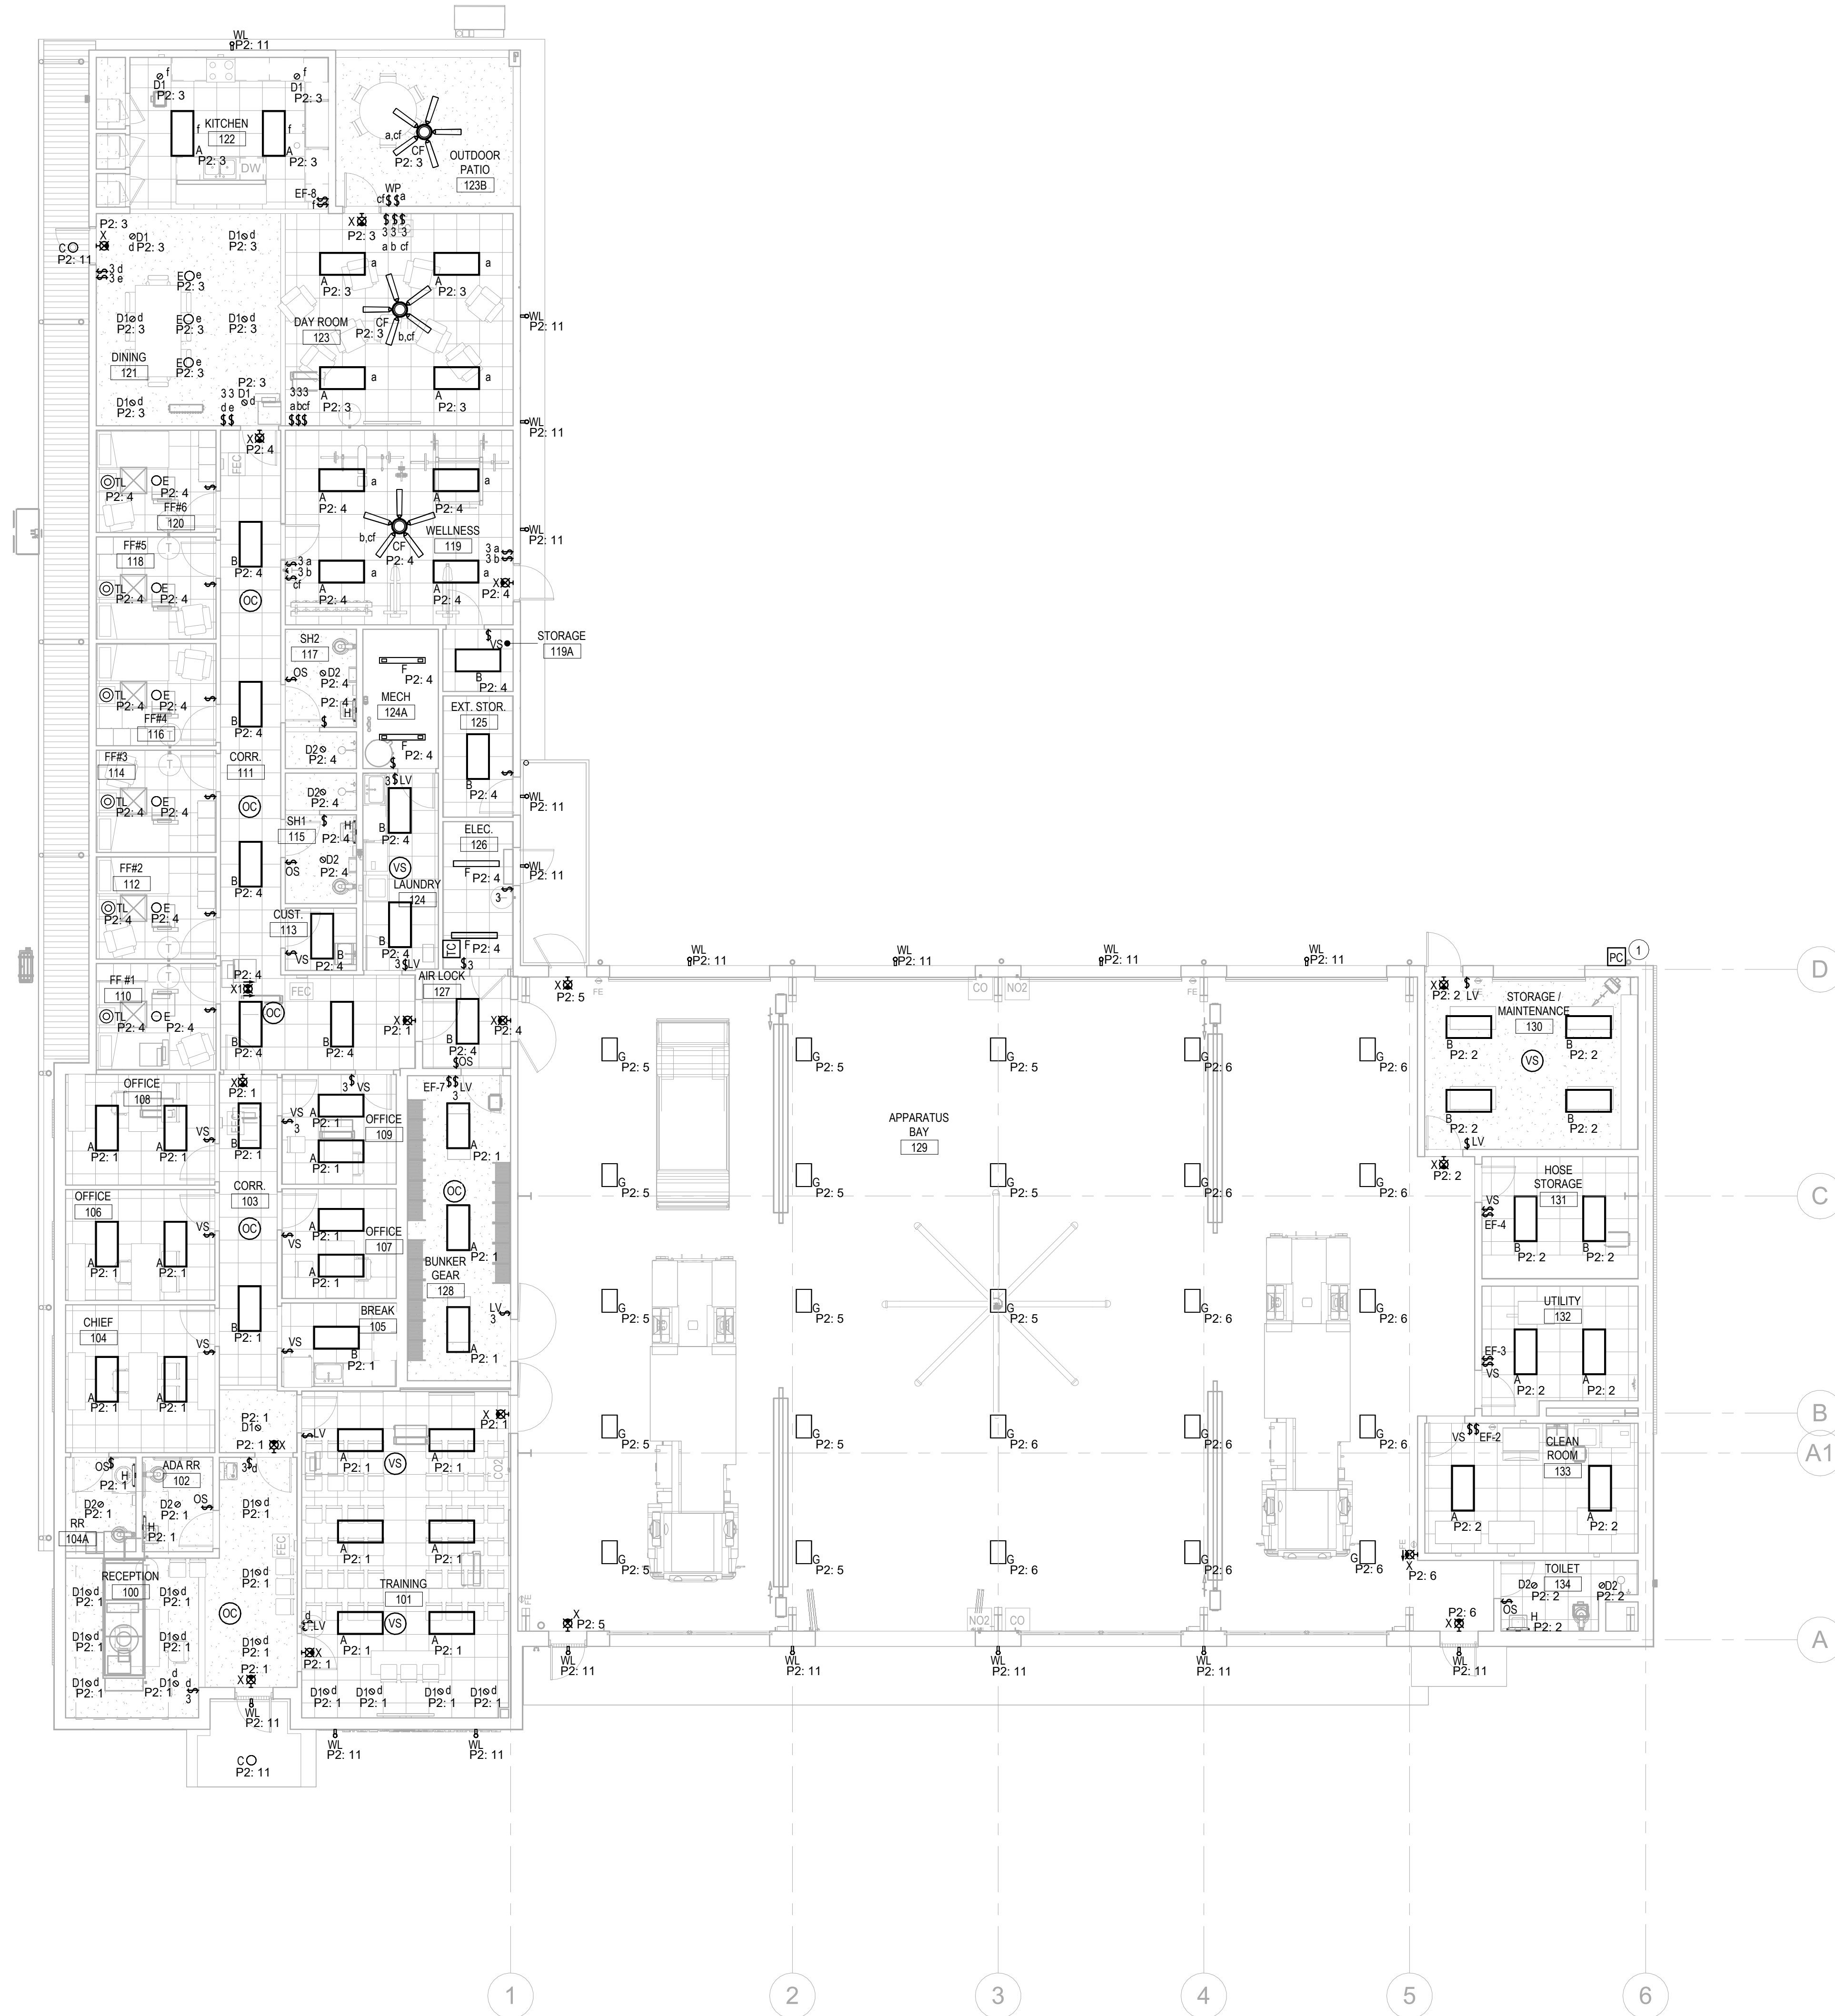

① FIRST FLOOR LIGHTING PLAN
1/8" = 1'-0"