


FILE PATH: Autocad Docs/REVIT 2025/26DLS035 Madison GA Fire Station, RESTL MEP P25.rvt
PRINTED: 8/31/2026 5:05:37 PM

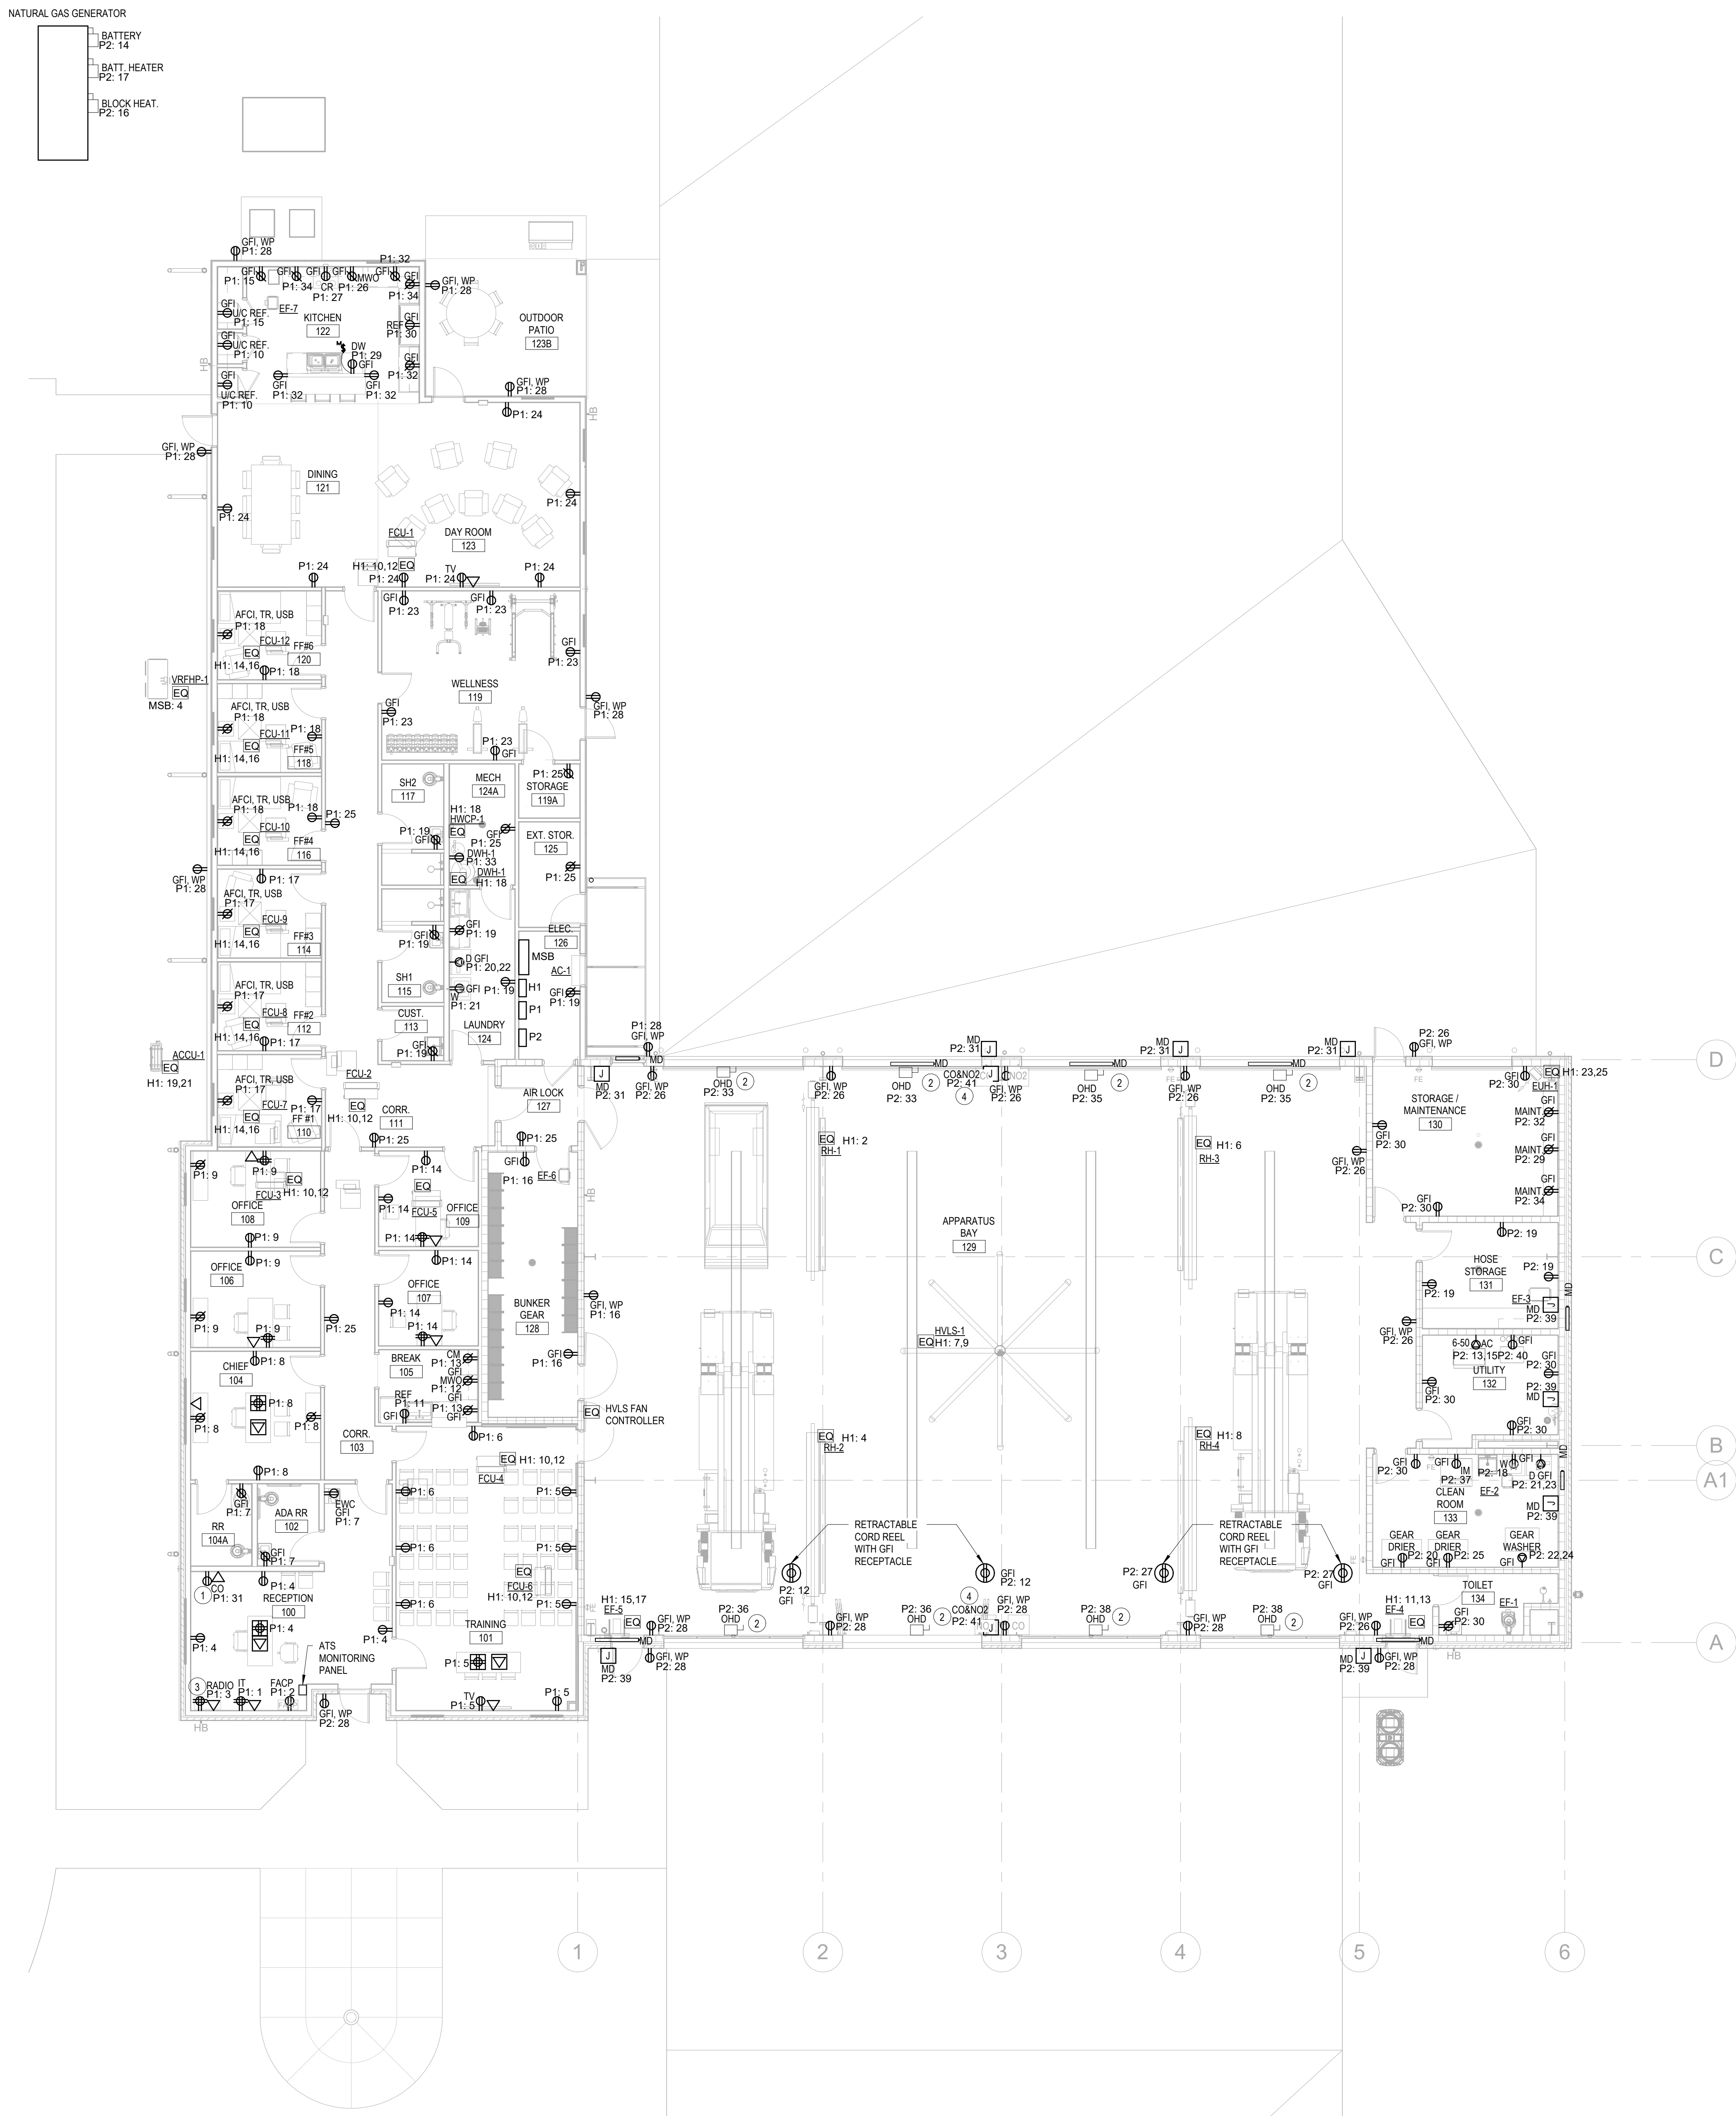

1 FIRST FLOOR POWER PLAN
1/8" = 1'-0"

ELECTRICAL - GENERAL NOTES

- ALL 125-VOLT, SINGLE-PHASE, 15-AMPERE AND 20-AMPERE RECEPTACLES INSTALLED WITHIN FIREFIGHTER (FF) SLEEPING QUARTERS, BUNKER ROOM SHALL BE ARC-FAULT-INTERRUPTER (AFCI) PROTECTED AND TAMPER-RESISTANT (TR) TYPE PER NEC 210.12 AND NEC 406.12.
- WHERE A SINGLE CIRCUIT MANDATES BOTH ARC-FAULT (AFCI) AND GROUND-FAULT (GFCI) PROTECTION PER THE NEC, THE CONTRACTOR SHALL PROVIDE AND INSTALL A DUAL-FUNCTION AFCI/GFCI CIRCUIT BREAKER WITHIN THE BRANCH PANELBOARD. ALL AFFECTED WALL RECEPTACLES SHALL BE SPECIFICATION-GRADE TAMPER-RESISTANT (TR) TYPE.

PLAN NOTES

- COORDINATE EXACT LOCATION OF COPPER WITH OWNER AT SITE PRIOR TO ROUGH-IN.
- EC TO COORDINATE WITH ARCHITECT AND OVERHEAD DOOR VENDOR FOR FINAL EQUIPMENT REQUIREMENTS, INCLUDING DISCONNECT SWITCH, CONTROL PANEL AND ALL REQUIRED ELECTRICAL CONNECTIONS, PRIOR TO ELECTRICAL ROUGH-IN.
- EC TO COORDINATE WITH THE ELV ENGINEER FOR FINAL ELECTRICAL REQUIREMENTS OF RADIO EQUIPMENT, ELV, IT SYSTEM LOCATIONS OF ALL EQUIPMENTS AND DEVICES PRIOR TO ROUGH-IN.
- PROVIDE FA INTERFACE FOR CO & NO2, COORDINATE WITH HVAC ENGINEER AND EQUIPMENT SUPPLIER, FOR THE ACTUAL LOCATION



11 Ninth Street, Suite 120
Columbus, GA 31901
P. (706) 571-6923



5757 Alpha Road, Suite 201
Dallas, TX 75201



RFP 2027-3500-01

FIRE STATION MADISON, GA

1100 MARY MAGNAN BLVD
MADISON, GA 30650

BID DOCUMENTS

Project No.: 25-02527
Date: 08/31/26
Drawn by: VVR
Checked by: CM
Revisions:

No.	Date	Description
-----	------	-------------

FIRST FLOOR
POWER PLAN

E310