


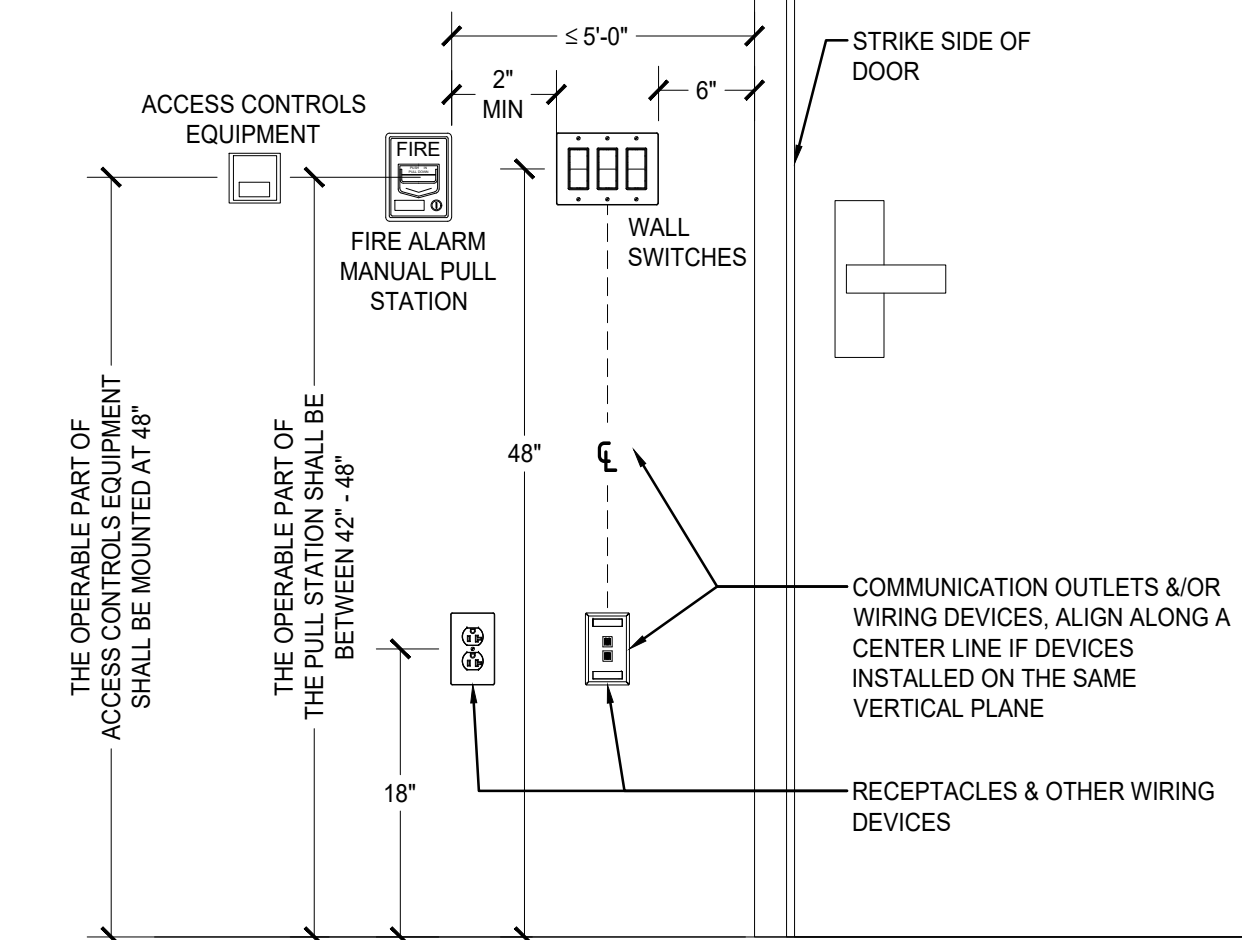


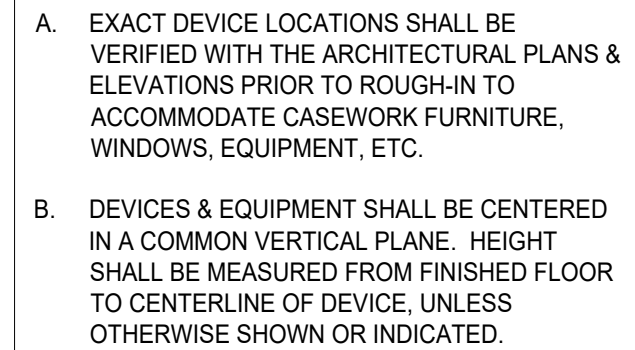


1 TYPICAL DEVICE & EQUIPMENT INSTALLATION HEIGHTS

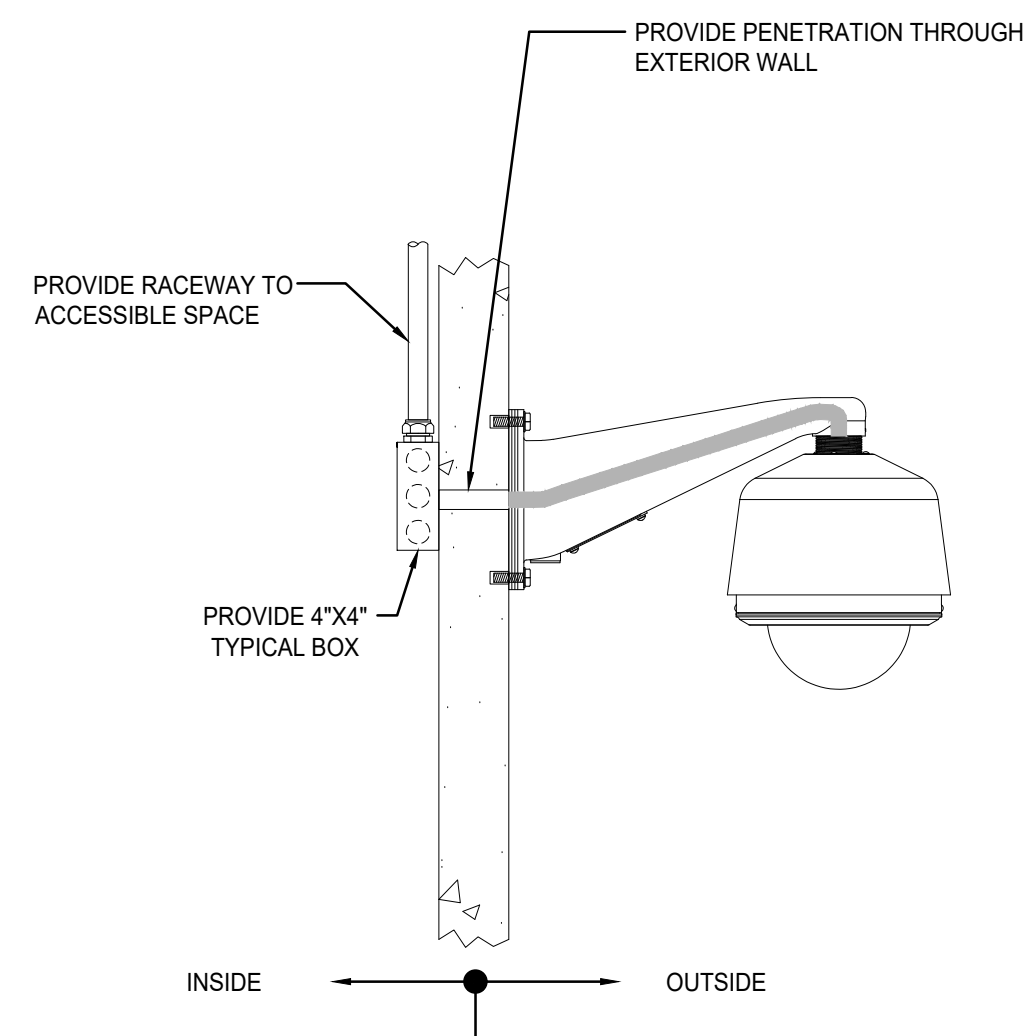

4 EXTERIOR WALL MOUNTED
TYPICAL CCTV CAMERA DETAIL
SCALE: NONE

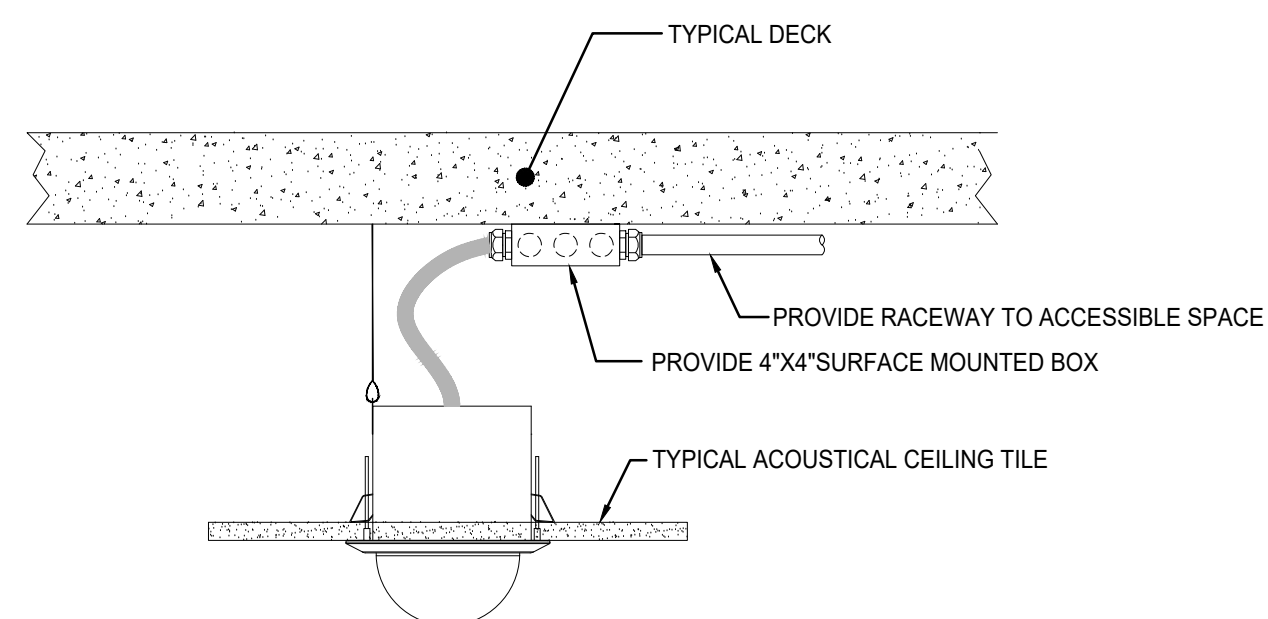

INTERIOR FLUSH CEILING MOUNTED
TYPICAL CCTV CAMERA DETAIL
5 SCALE: NONE

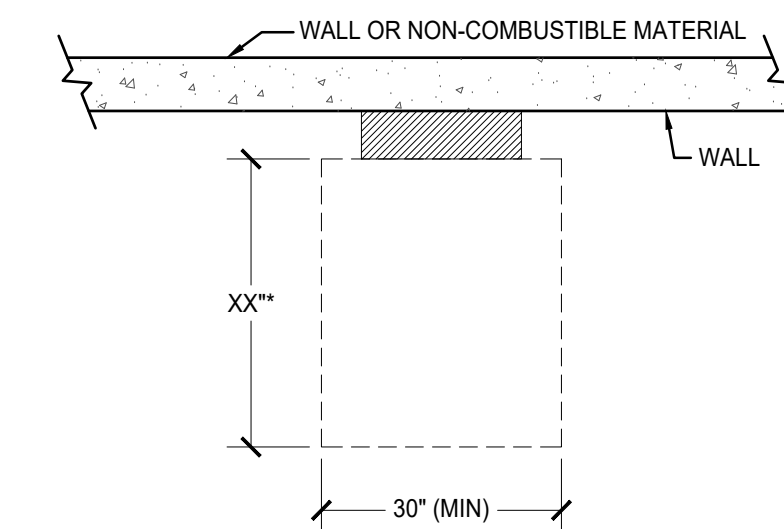


WALL MOUNTED PANELS

(INCLUDING POWER PANELS, CONTRACTORS, CONTROL CABINETS, DISCONNECT SWITCHES, MOTOR STARTERS, TIME CLOCK & SIMILAR ELECTRICAL EQUIPMENT)

NOTES:

- A. XX" IDENTIFIES MINIMUM WORKING SPACE CLEARANCE REQUIREMENTS
(IN THE DIRECTION OF ACCESS TO LIVE PARTS AS REQUIRED PER NFPA 70, SECTION 110.28(a))
- 36" FOR 0-150V PHASE TO GROUND ELECTRIC EQUIPMENT.
 - 42" FOR 150-600V PHASE TO GROUND EQUIPMENT (CONDITION 2 "LIVE TO GROUND")
 - 48" FOR 150-600V PHASE TO GROUND EQUIPMENT (CONDITION 3 "BETWEEN LIVE EQUIPMENT")
- B. MINIMUM WORKING SPACE HEAD ROOM SHALL BE 7'8" AFF.

2 TYPICAL ELECTRICAL EQUIPMENT CLEARANCES

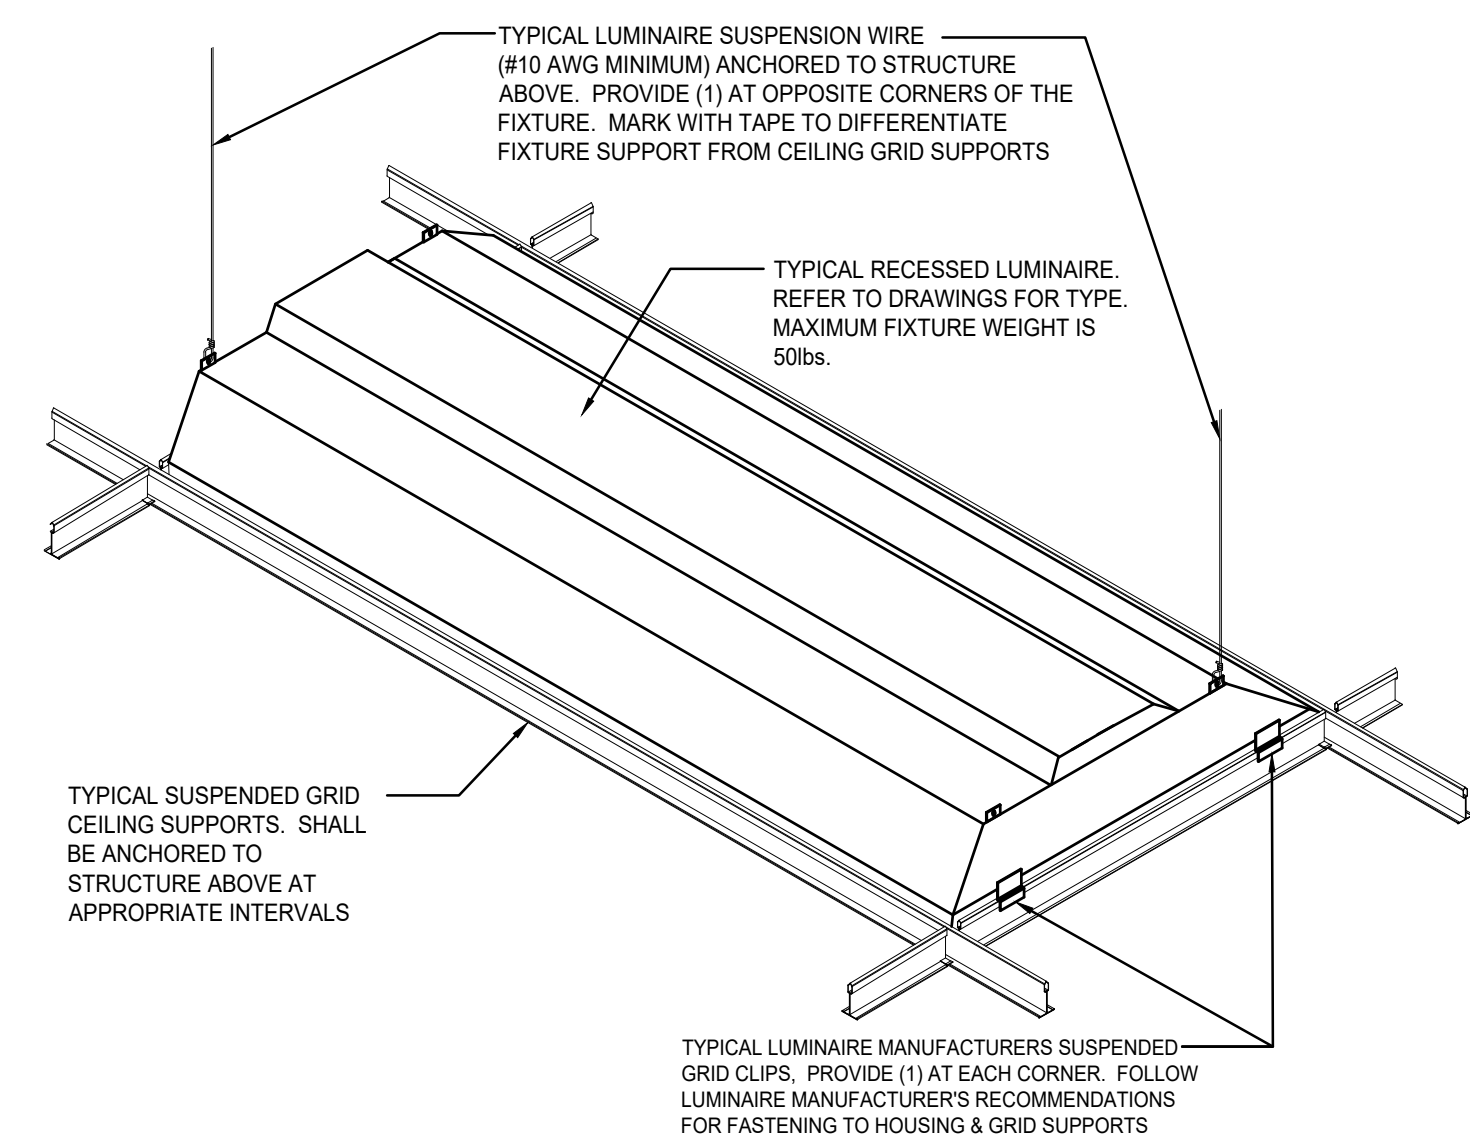

3 TYPICAL TROFFER INSTALLATION DETAIL



BROWN AND CALDWELL
900 HAMMOND DRIVE, SUITE 500
ATLANTA, GA 30328



THIS DRAWING IS NOT VALID
FOR CONSTRUCTION
PURPOSES UNLESS IT BEARS
THE SEAL AND SIGNATURE OF
A DULY REGISTERED
PROFESSIONAL



CONSTRUCTION
DOCUMENTS



NCWSA OFFICE
ADDITION

REVISIONS

[illegible]

LINE IS 2 INCHES
AT FULL SIZE

DESIGNED: MAP

DRAWN:	MAP
--------	-----

CHECKED: JFW

CHECKED:

APPROVED:

FILENAME

BC PROJECT NUMBER

616202

CLIENT PROJECT NUMBER

ELECTRICAL DETAILS

DRAWING NUMBER

E401