


B&L
BRANHAM & LLOYD, LLC
CONSULTING ENGINEERS
3345 HUTCHINSON ROAD
SUITE E, CUMMING, GA 30040
PHONE: (470) 416-0803
EMAIL: info@branhamlloyd.com



#	DATE

OCONEE
COUNTY

WATKINSVILLE,
GEORGIA

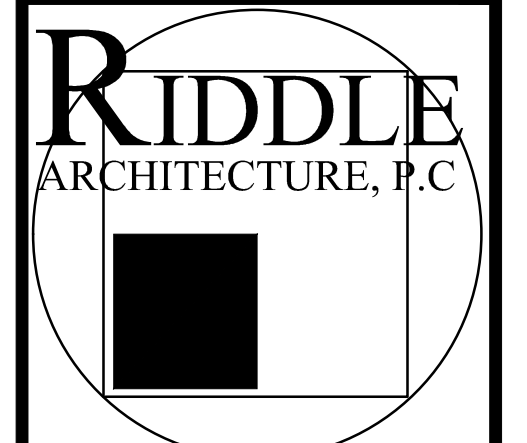

497 BROOMSEDGE COURT
BOLIVIA, NC
28422
(404) 285-8646


TITLE: SITE PLAN -
ELECTRICAL

JOB #: 2502
DATE: 09.11.26

SHEET #

EO

- ① NEW 100KVA 208-VOLT 3-PHASE OWNER FURNISHED GENERATOR.
- ② NEW PULL BOX.
- ③ APPROXIMATE CONDUCTOR ROUTING UNDERGROUND.
- ④ NEW 400A OWNER FURNISHED ATS.
- ⑤ NEW 400A MAIN SWITCH GEAR.
- ⑥ COORDINATE LOCATION AND POWER REQUIREMENTS FOR LIFT STATION BY OTHERS. INSTALL ON UNI-STRUT FRAME.
- ⑦ ROUTE STARTING WIRES TO ATS.
- ⑧ 20A/1P, 2#12, #12G, 3/4" TO PANEL A-54 FOR BATTERY CHARGER
- ⑨ 20A/2P, 3#12, #12G, 3/4" TO PANEL A-56,58 FOR BLOCK-HEATER.

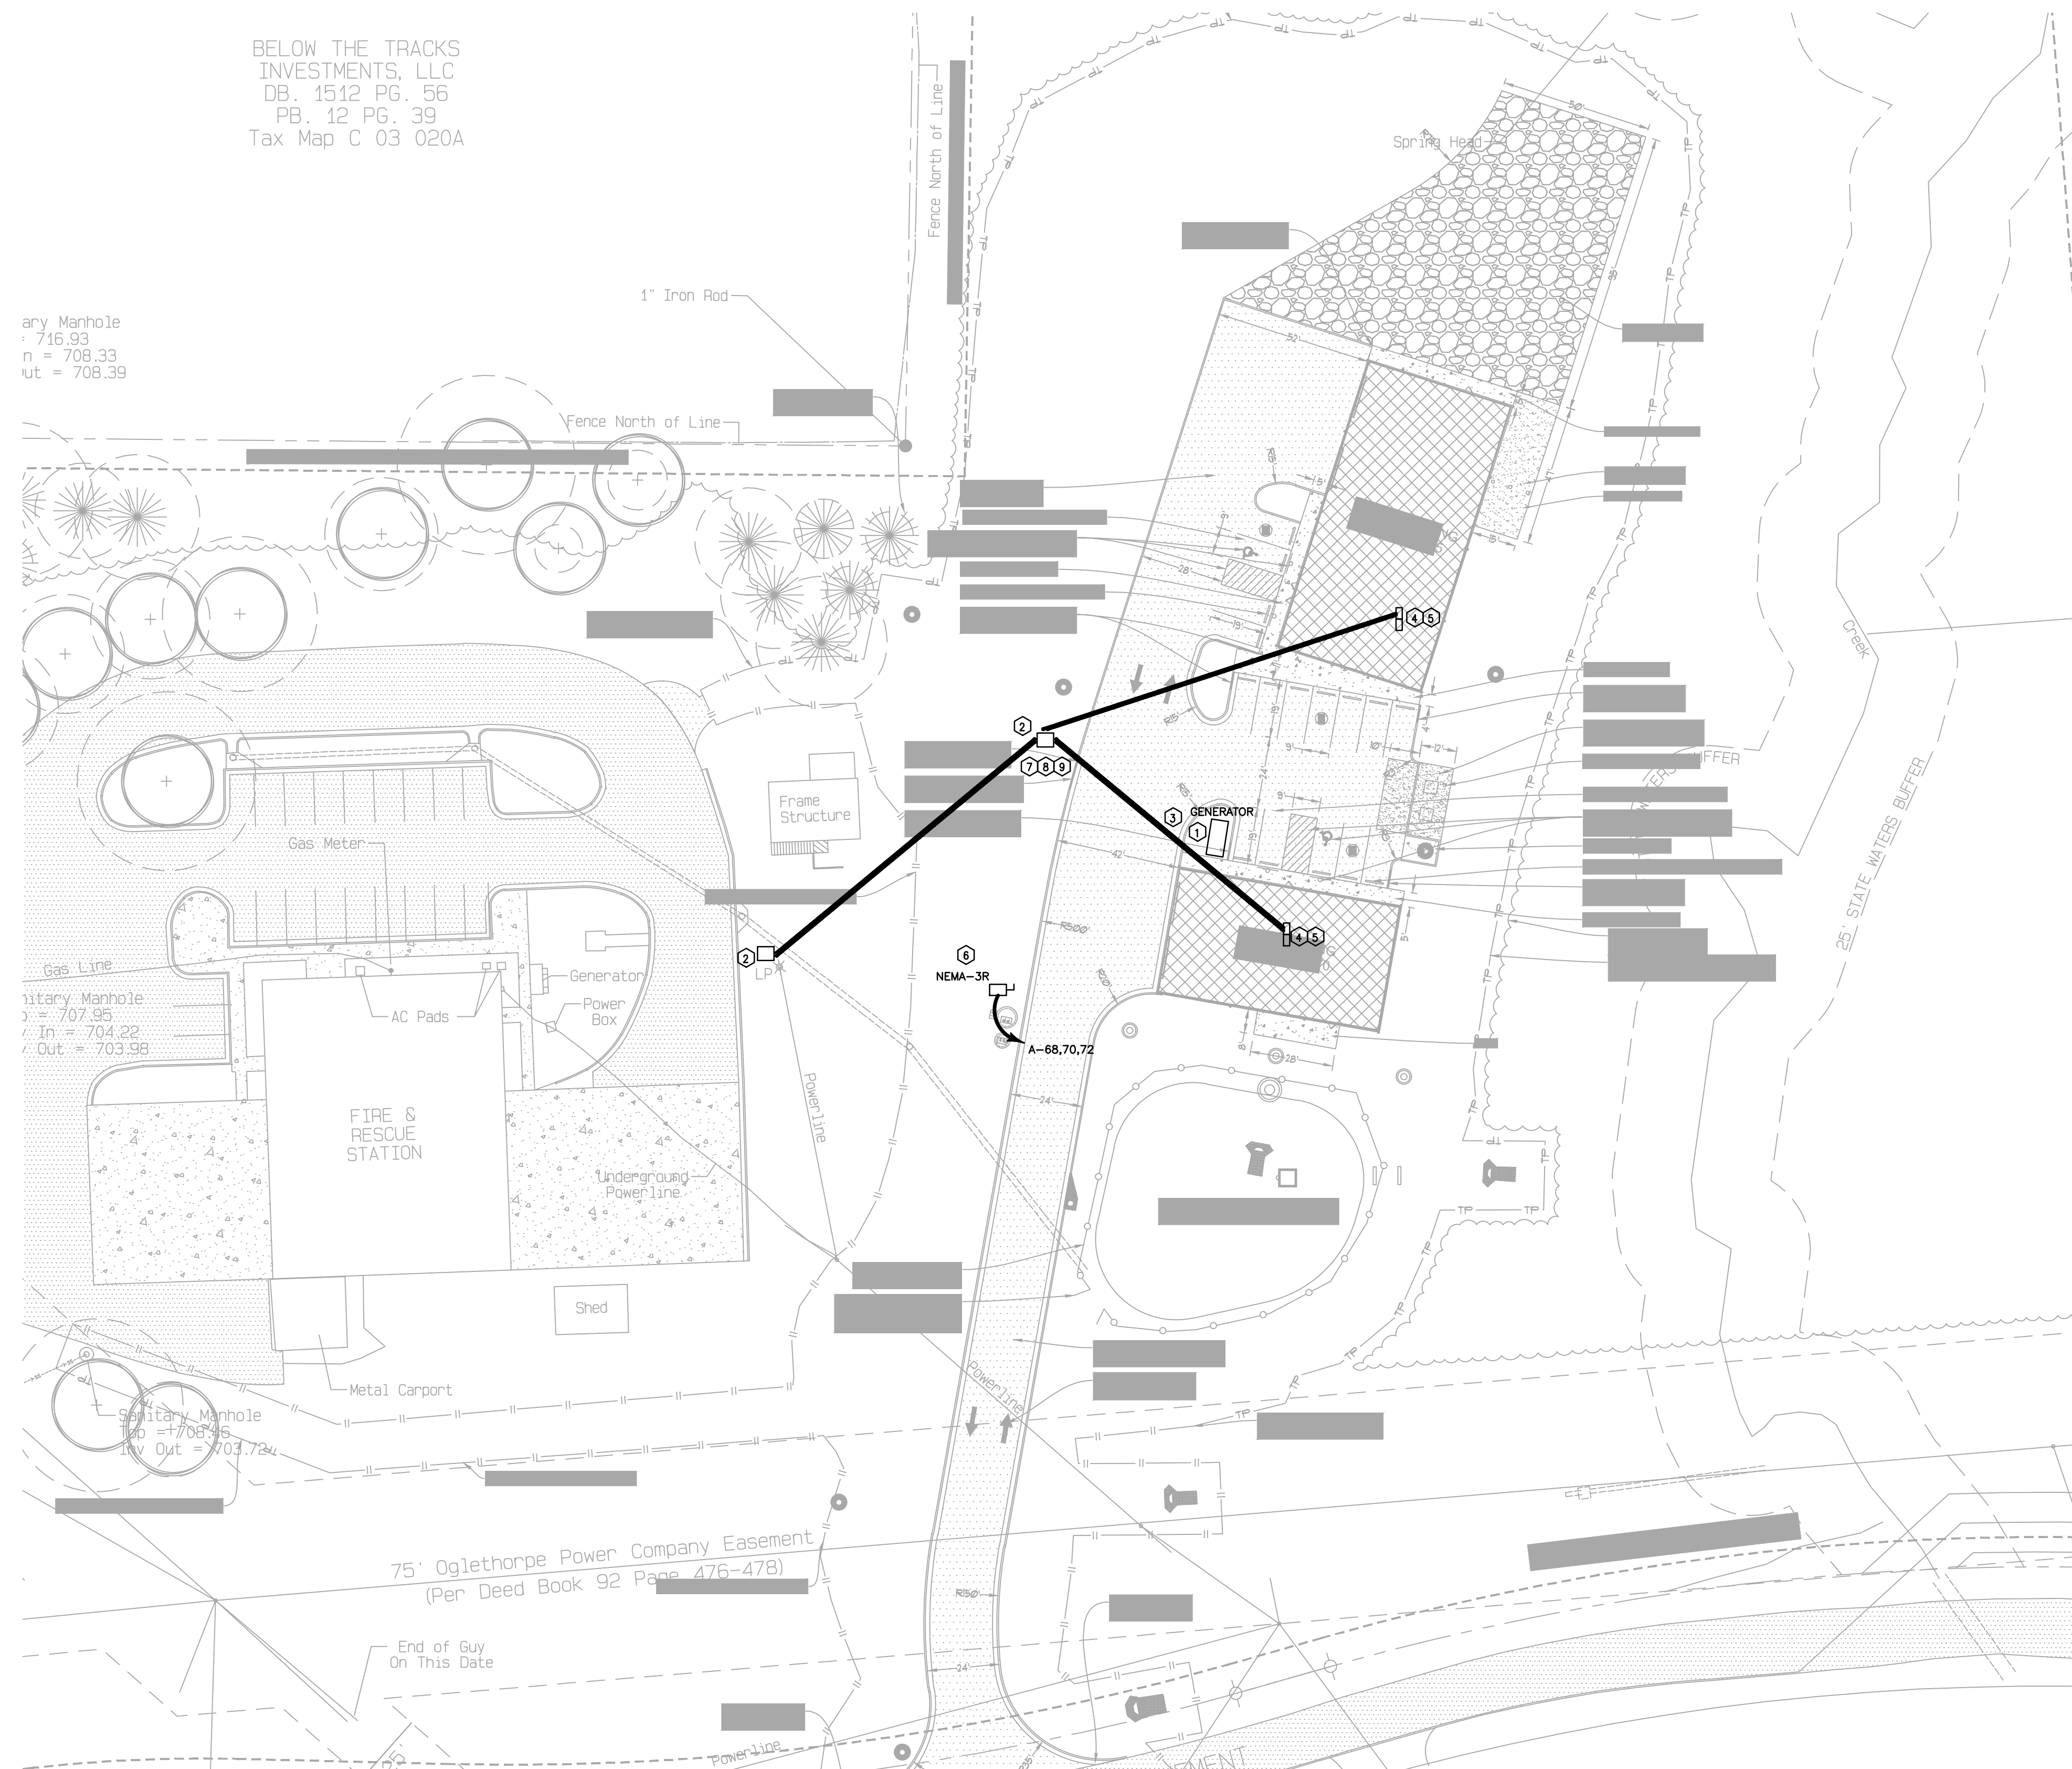
$$\frac{1}{E1}$$

SITE PLAN – ELECTRICAL

SCALE: 1"= 30'-0"