

KEY NOTES:

- ① PROVIDE 3/4" CONDUIT PATHWAY WITH PULL STRINGS FROM CAMERA TO NVR. CAMERA SHALL BE HANWAHA VISION PNM-12082RVD MULT-DIRECTIONAL CAMERA. COORDINATE MOUNTING HEIGHT WITH ARCHITECT/OWNER.
- ② PROVIDE (2) 3/4" CONDUIT PATHWAY WITH PULL STRINGS FROM CR TO ACP.
- ③ PROVIDE 120V CIRCUIT TO ACP, PS AND NVR.


REVISIONS

#	DATE

A NEW
FACILITIES
SHOP
FOR:

OCONEE
COUNTY

WATKINSVILLE,
GEORGIA

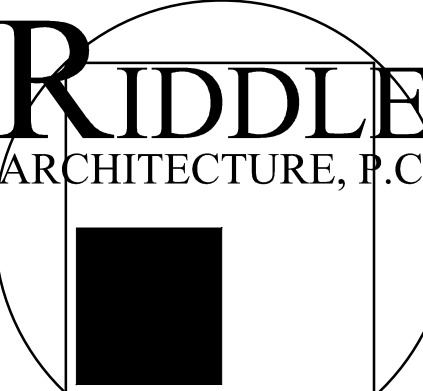


497 BROOMSEDGE COURT
BOLIVIA, NC
28422
(404) 285-8646

TITLE: FLOOR PLAN -
LOW VOLTAGE

JOB #: 2501
DATE: 09.11.26

SHEET #

E2.1

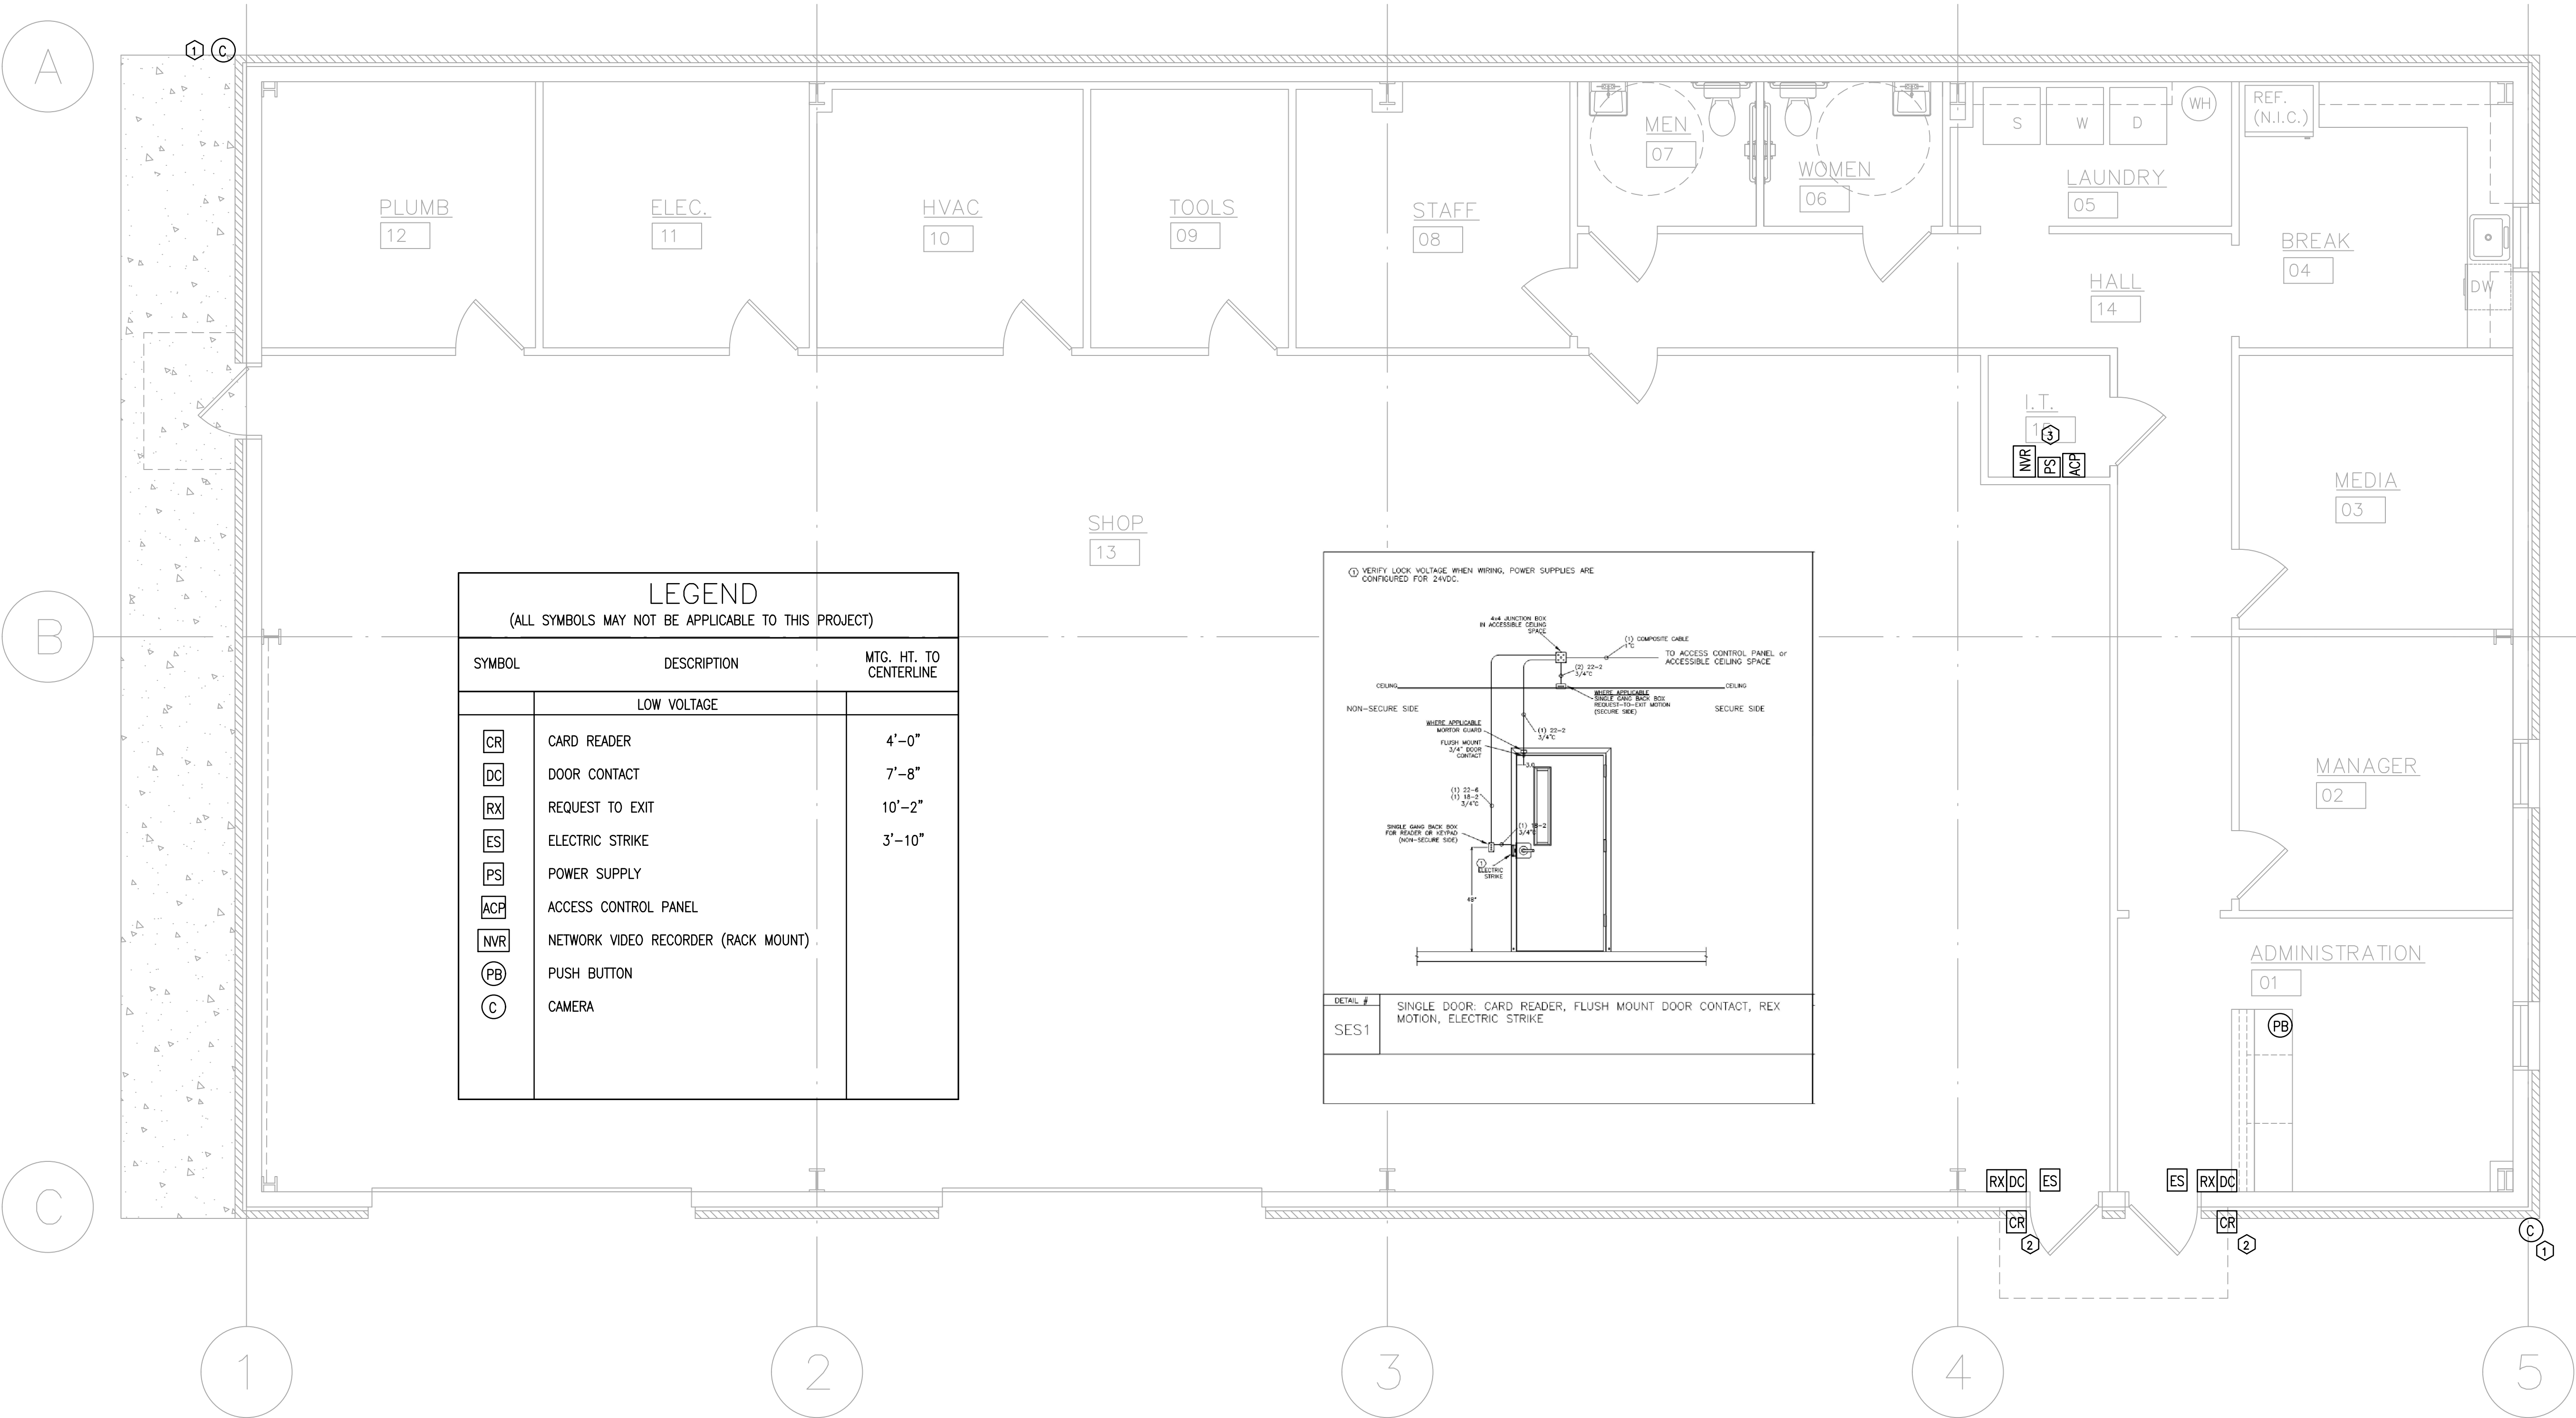

1 FLOOR PLAN – LOW VOLTAGE
E2.1 SCALE: 1/4" = 1'-0"