

DOMESTIC NOTES:

- 1 WATER SERVICE ENTRANCE. BACKFLOW PREVENTION PROVIDED BY CIVIL.
- 2 3/4" CW AND 3/4" HW TO WATER HEATER. SEE DETAIL.
- 3 1/2" CW DOWN TO FIXTURE WITH SHUT-OFF VALVE.
- 4 1/2" CW AND 1/2" HW DOWN TO FIXTURE WITH SHUT-OFF VALVES.
- 5 PROVIDE 1/2" CW DOWN TO ICE MAKER BOX (IM).
- 6 3/4" CW AND 3/4" HW DOWN TO FIXTURE WITH SHUT-OFF VALVES.
- 7 3/4" CW DOWN TO FIXTURE WITH SHUT-OFF VALVE.


REVISIONS

#	DATE

A NEW
FACILITIES
SHOP
FOR:

OCONEE
COUNTY

WATKINSVILLE,
GEORGIA

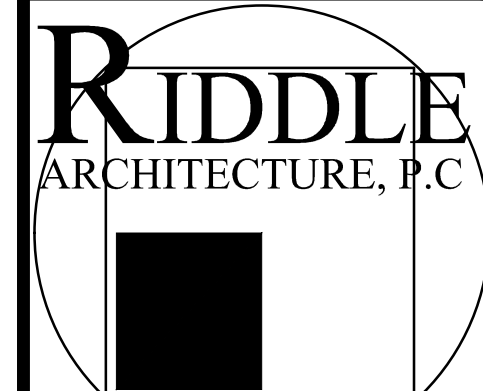


AMERICAN
INSTITUTE
OF
ARCHITECTS
497 BROOMSEDGE COURT
BOLIVIA, NC
28422
(404) 285-8646

TITLE: FLOOR PLAN -
DOMESTIC

JOB #: 2501
DATE: 09.11.26

SHEET #
P1

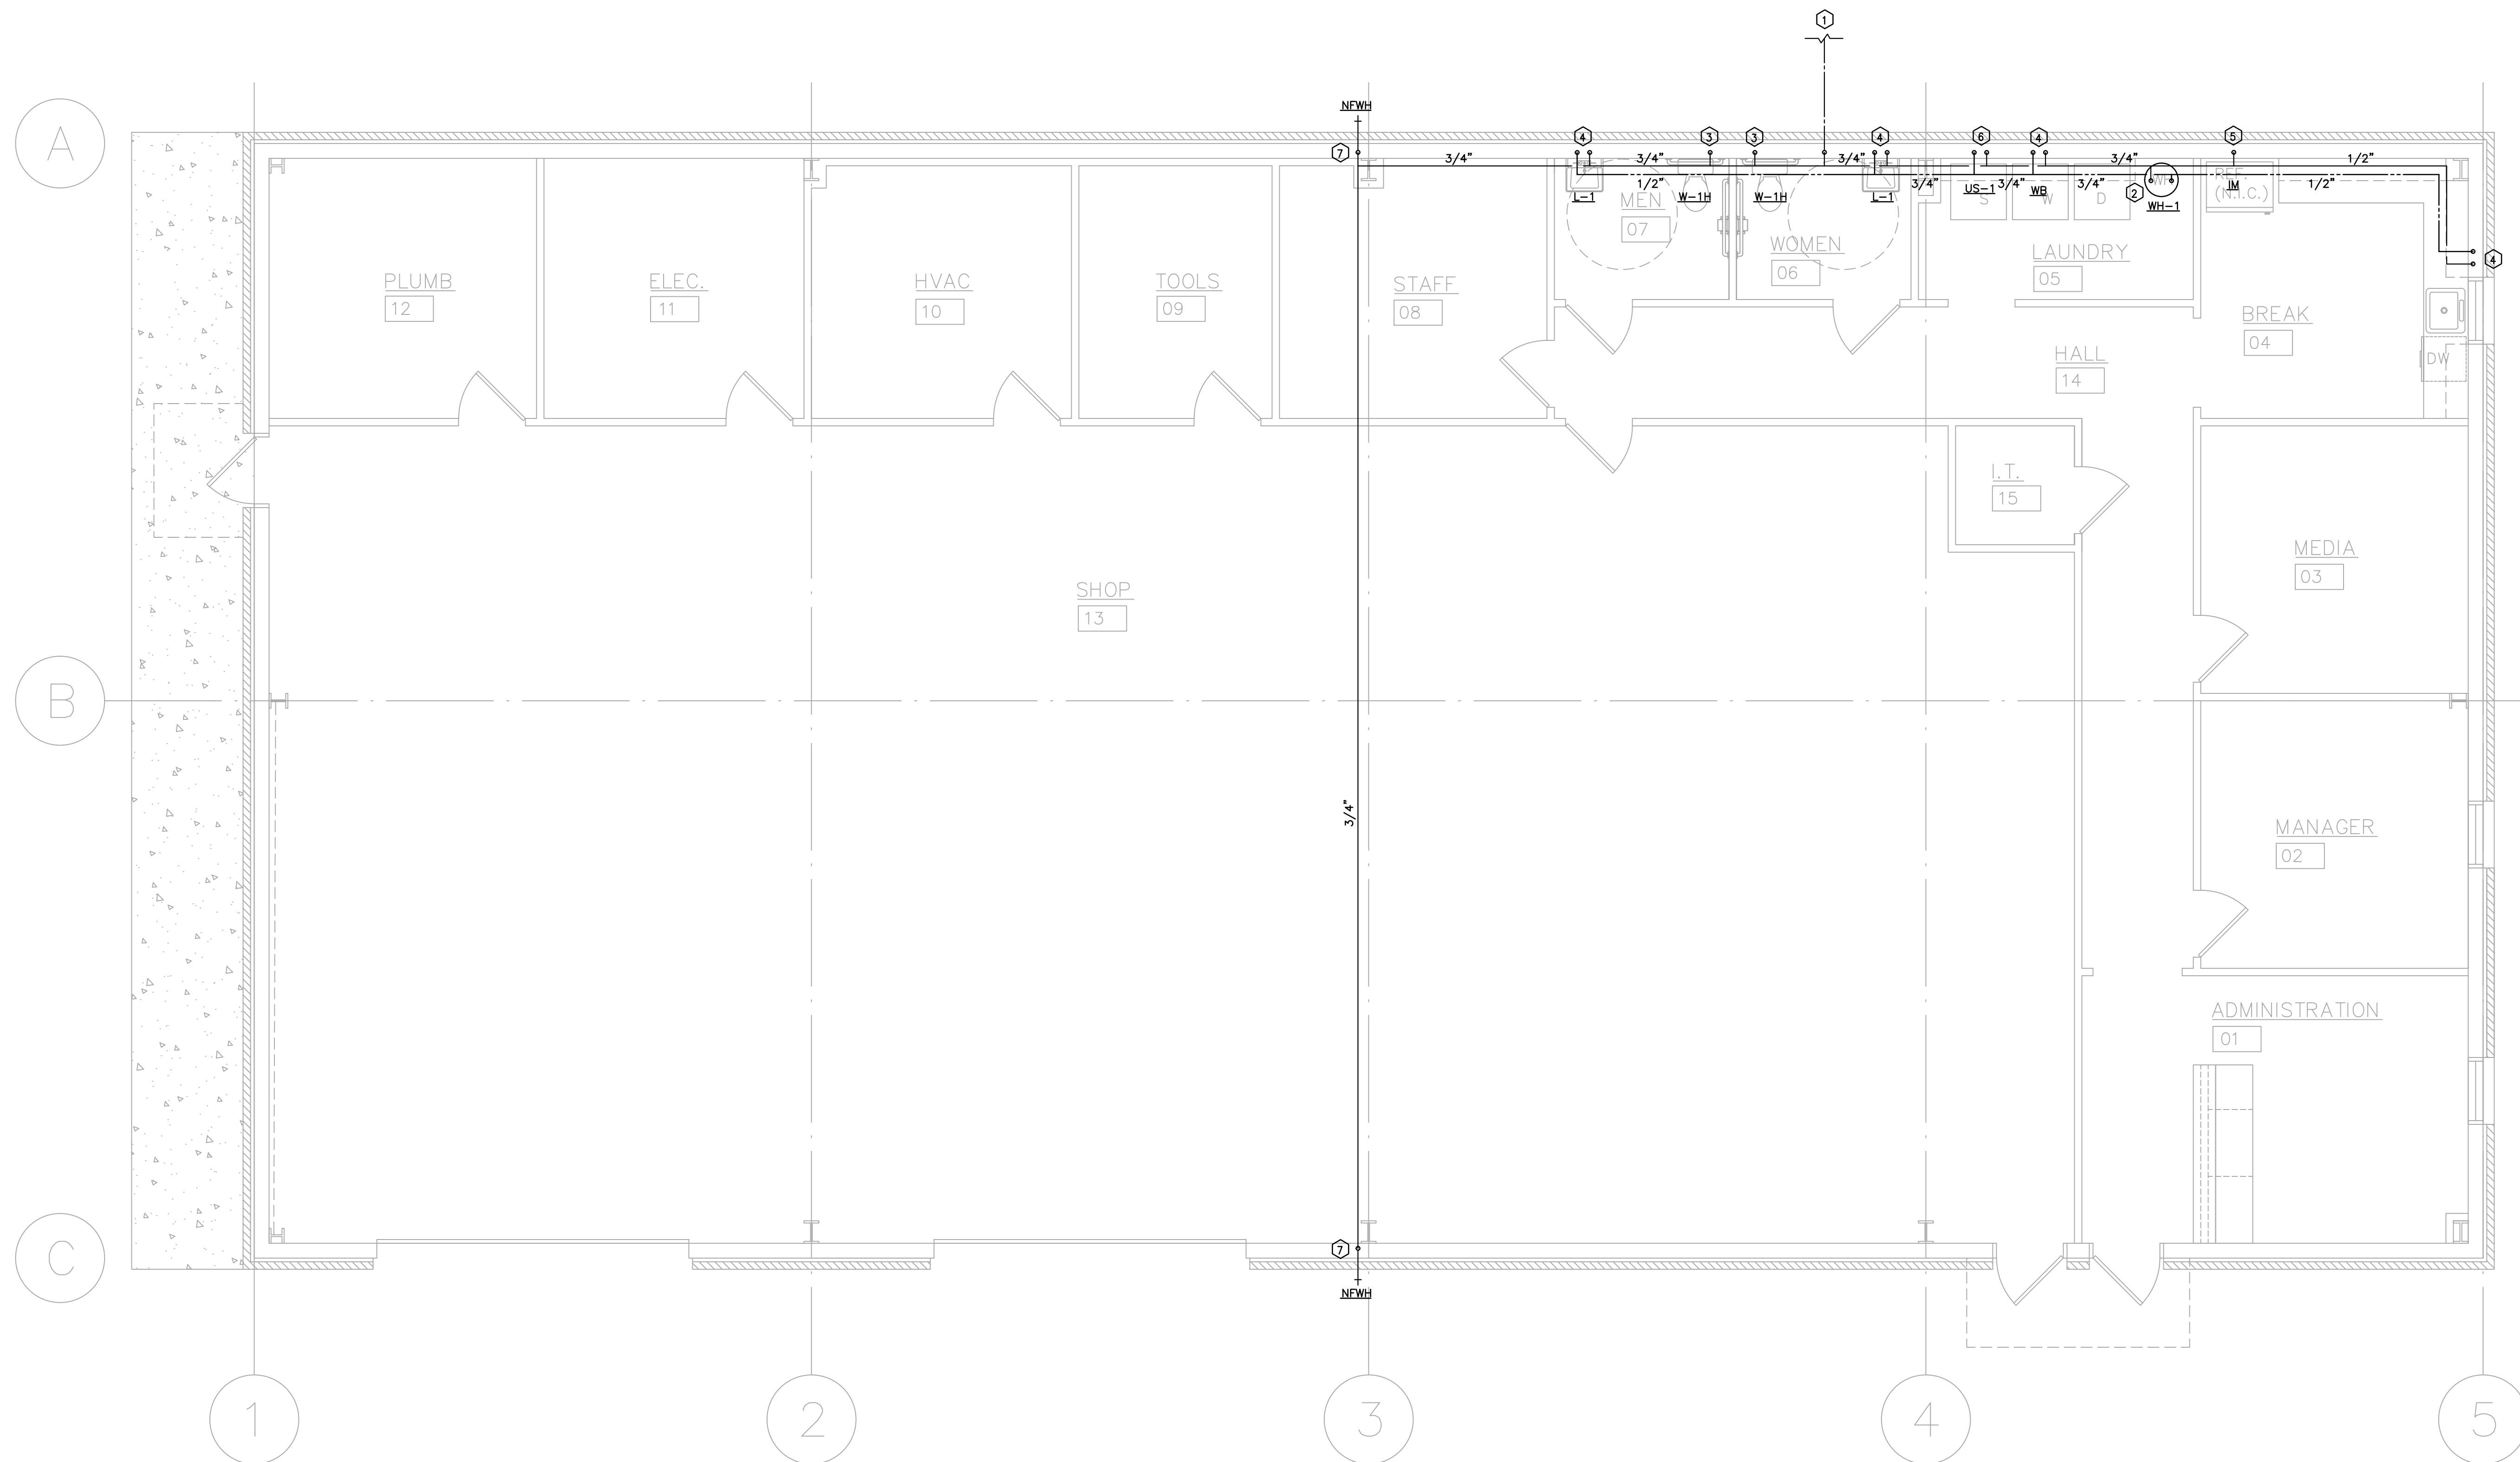

1 FLOOR PLAN – DOMESTIC
P1 SCALE: 1/4" = 1'-0"