


NOTE:
ALL HOMERUNS TO DIMMING
PANEL TO BE #10 AWG MINIMUM

(THIS SHEET ONLY)

- | | |
|--|---|
| <p>1. MOTION DETECTOR W/LED TO OPERATE LIGHTS INSTALL AT 8'4" AFF. DETECTOR EQUAL TO SENSOR SWITCH BUS-ED -FOT-U.</p> | <p>5. PROVIDE KEY OPERATED 3-WAY SWITCHES TO CONTROL A 4-POLE CONTACTOR THAT TURNS CORRIDOR LIGHTS OFF/ON.</p> |
| <p>2. THIS FIXTURE SHALL HAVE BODINE "GTD", GENERATOR TRANSFER DEVICE INSTALLED TO PROVIDE TRANSFER AND PROVIDE UNSWITCHED POWER FROM LIGHTING CIRCUIT AND POWER FROM GENERATOR PANEL.</p> | <p>6. MASTER DIMMING CONTROLLER LOCATED IN SOUND BOOTH.</p> |
| <p>3. JUNCTION BOX AT BOTTOM CHORD OF ROOF STRUCTURE FOR FUTURE CONNECTION TO LIGHTING WIRE CIRCUIT NUMBER ON COVERPLATE.</p> | <p>7. FLUSH MOUNTED REMOTE DIMMING SYSTEM CONTROL PANEL AT 8'4" AFF. COORD. EXACT LOCATION WITH DIMMING SYSTEM INSTALLER.</p> |
| <p>4. TWI-FLOCK RECEPTACLE WITH SPRING LOADED COVERPLATE FOR FOLLLO SPOT PLUG. PROVIDE 3/8" & 1/8"OD - 1/2"O. TO DIMMER RACK.</p> | |
| <p>8. 2# 1/8"OD - 3/4"O. TO PANEL.</p> | |
| <p>9. TO CORRIDOR LTG. CONTACTOR.</p> | |

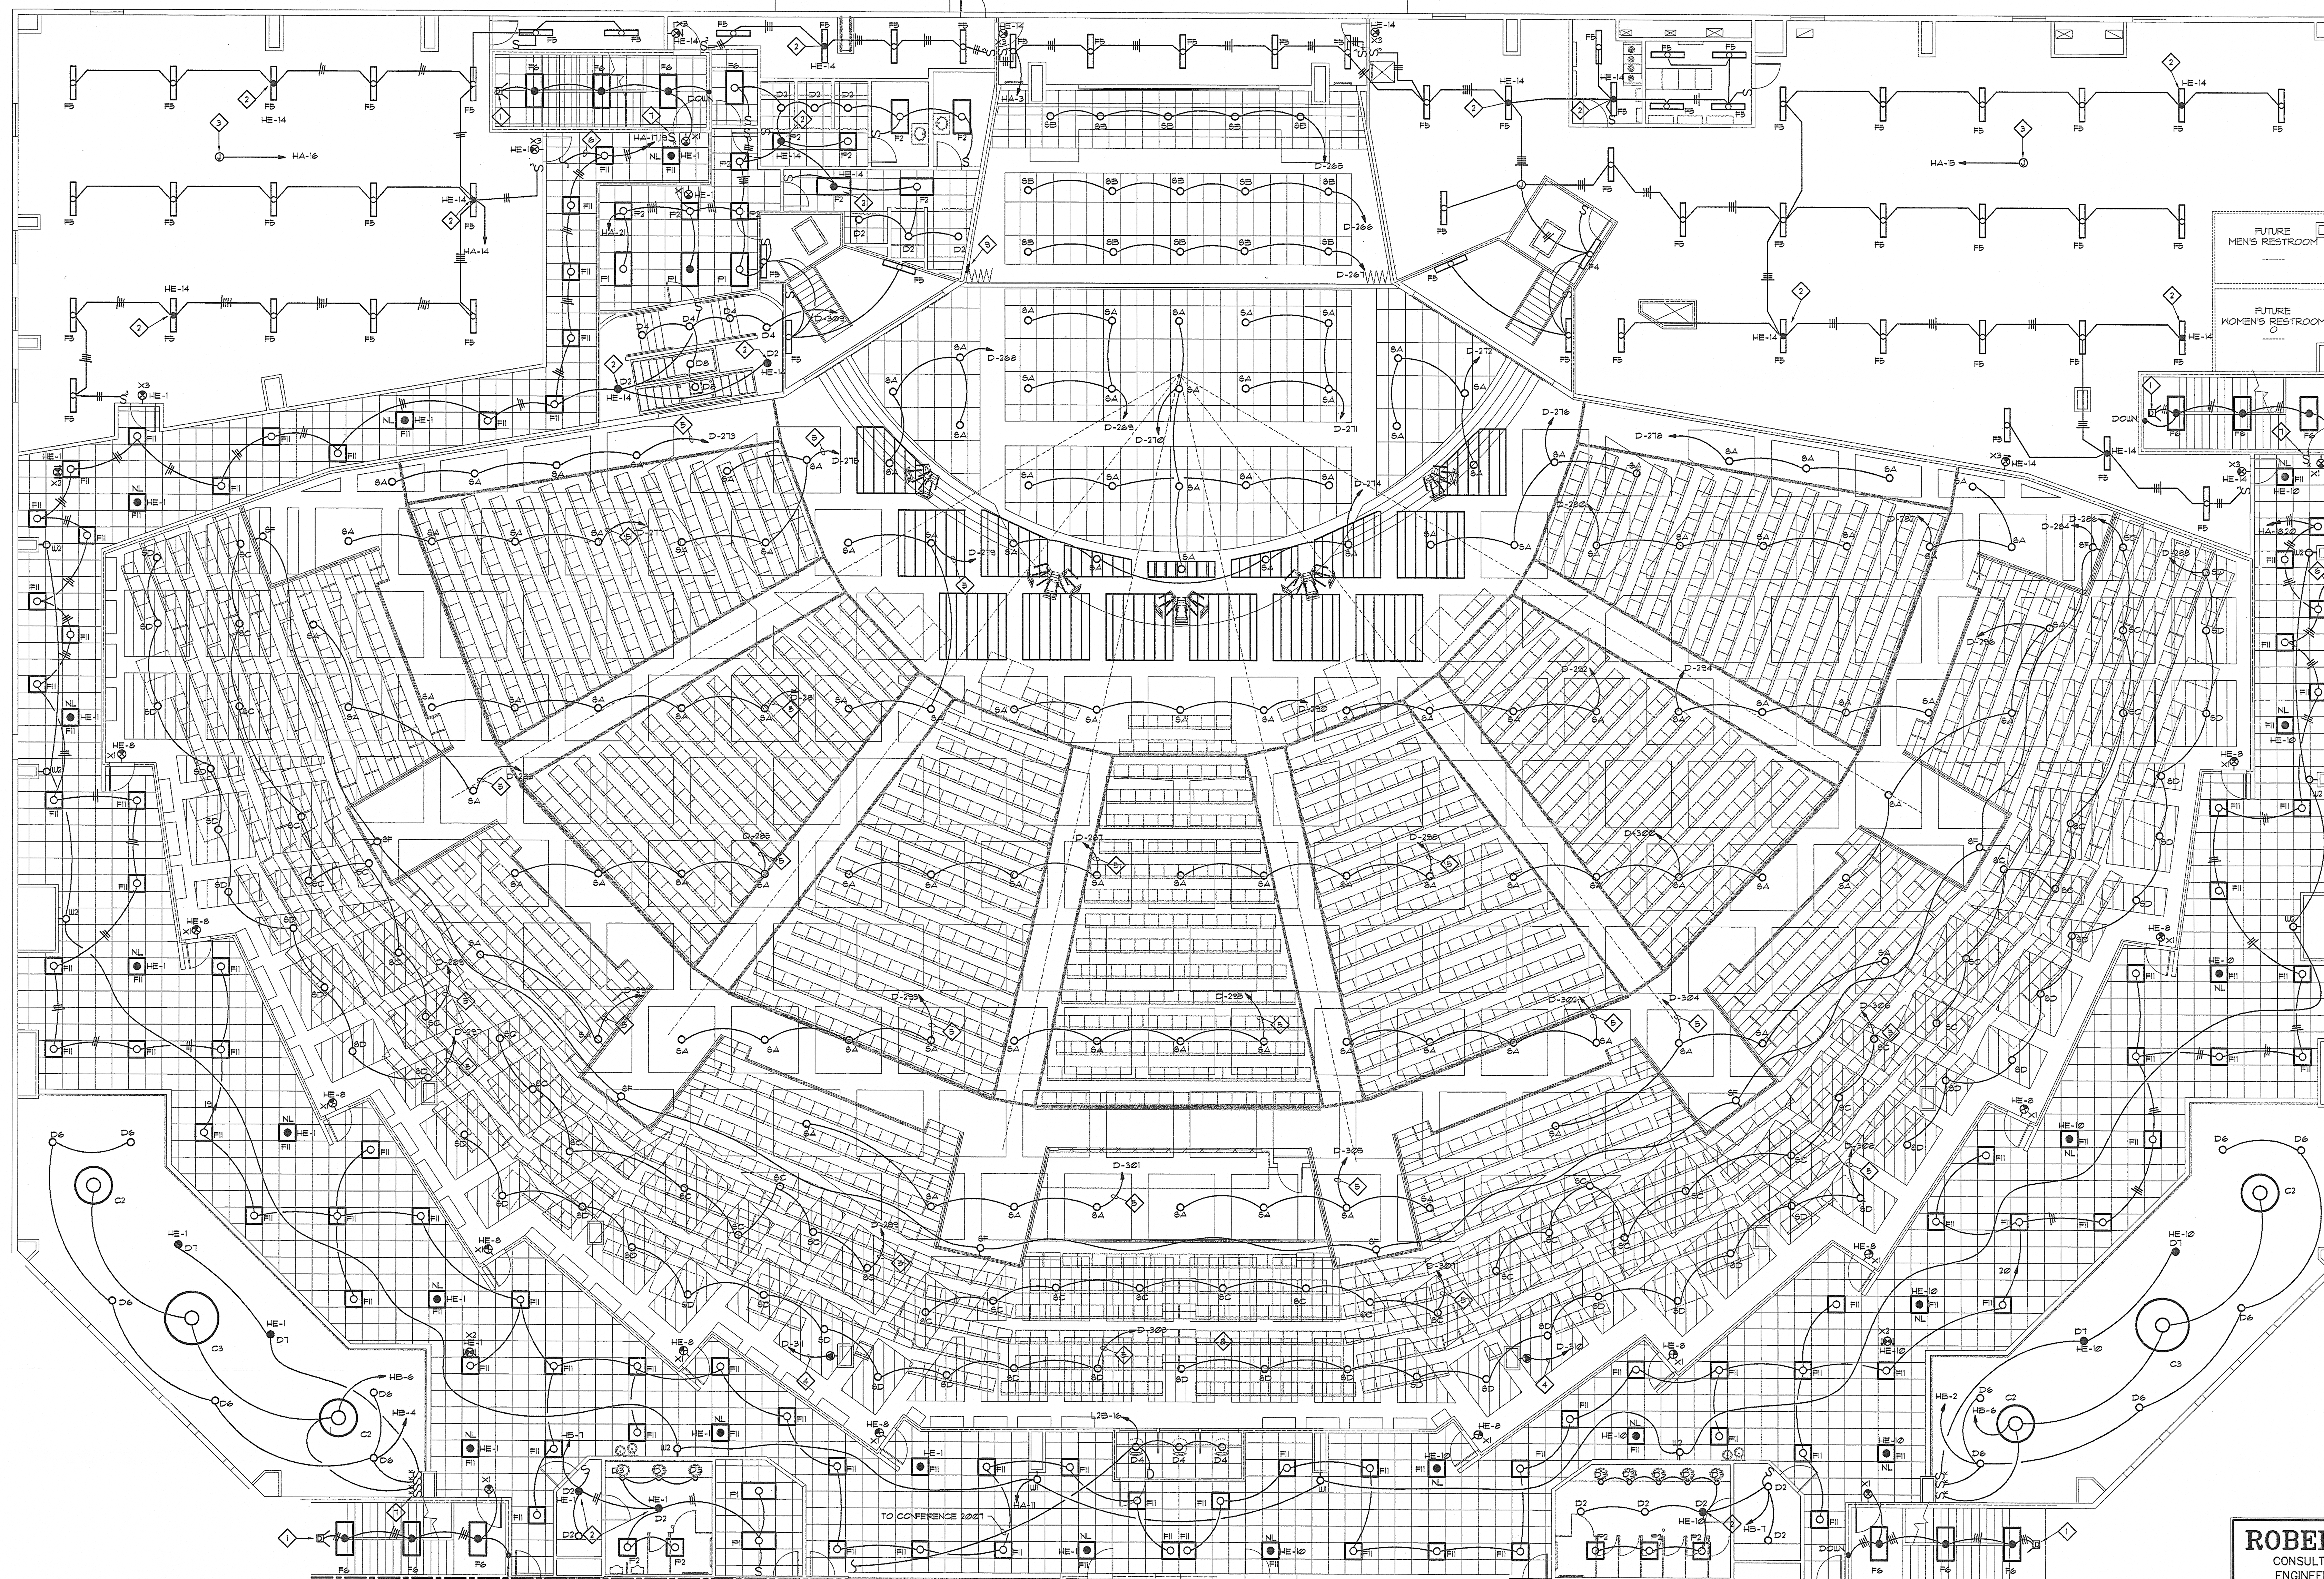

1 SECOND FLOOR REFLECTED CEILING PLAN - PART 1 - LIGHTING
F-III SCALE: 1/8" = 1'-0"

ROBERDS
CONSULTING
ENGINEERS

ENGINEERS
455 EAST PACES FERRY ROAD, N.
SUITE 300
ATLANTA GEORGIA 30305
TELEPHONE (404) 237-8632
FACSIMILE (404) 237-4161


revisions

for construction

This drawing, as an instrument of service, is and shall remain the property of the Architects and Engineers and shall not be reproduced, published or used in any way without the written permission of the Architect or Engineer.

Copyright ©1998 By
John Ware & Associates, Inc.

seal

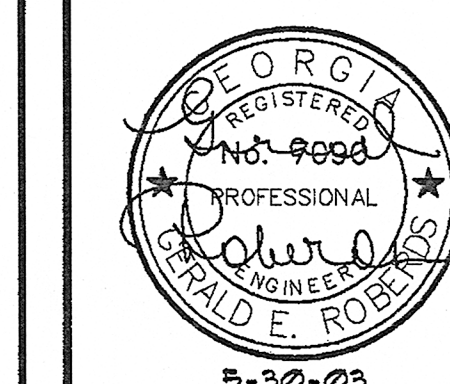

**John Ware
&
Associates,
Inc.**

Architects & Engineers

1954 Airport Road
Suite 100
Atlanta, GA 30341
(770) 451-1921
FAX (770) 457-1920

project
**CHURCH
IN THE NOW**

address
1873 & 1933
IRIS DRIVE
CONYERS, GA
for
**COVENANT
SERVICES, IN**
1777 WESLEY WAY
CONYERS, GA

sheet description
SECND. FLOOR
REFL. CEILING
PLAN- PART 1
-LIGHTING
 drawn VJ
 checked TUM

job 00-145
date 12/20/00

E-111